

NOTES:

1. CURRENT OWNER INFORMATION WAS TAKEN FROM THE LOUDOUN COUNTY REAL ESTATE TAX ASSESSMENT AND PARCEL DATABASE. THE PROJECT IS COMPOSED OF THE FOLLOWING PARCELS AMONG THE LAND RECORDS OF LOUDOUN COUNTY, VIRGINIA:

MCP#	TAX MAP#	PARCEL	DB & PG	OWNER	AREA
231-19-0774	48/	107/	201210250084145	LEESBURG ACQUISITION PARTNERS LLC	81,978 S.F. 1.88 AC
231-19-3353	48/K/2/	107/	201210110079755	LEESBURG ACQUISITION PARTNERS LLC	348,246 S.F. 7.99 AC
231-19-6044	48/K10/	107/3/	201210110079755	LEESBURG ACQUISITION PARTNERS LLC	24,789 S.F. 0.57 AC
231-19-6022	48/K10/	107/2/	201210110079755	LEESBURG ACQUISITION PARTNERS LLC	52,666 S.F. 1.21 AC
231-19-2572	48/	107A	DB 940, PG 513	AT&T COMMUNICATIONS OF VA, INC.	5,227 S.F. 0.12 AC

THE TOTAL SITE AREA IS 11.77 ACRES.


- BOUNDARY INFORMATION SHOWN HEREON WAS TAKEN FROM AN ALTA/ACSM LAND TITLE SURVEY PREPARED BY BOWMAN CONSULTING GROUP ON 12/28/2011 AND REVISED 9/17/2012.
- THIS PROPERTY IS CURRENTLY ZONED PRN WITH PORTIONS OF THE PROPERTY IN THE CREEK VALLEY BUFFER OVERLAY DISTRICT AND AIRPORT OVERLAY DISTRICT PER THE TOWN OF LEESBURG ZONING ORDINANCE.
- A REDUCTION OF THE CREEK VALLEY BUFFER WILL BE REQUESTED FOR THE PROPOSED DEVELOPMENT AS PERMITTED BY SECTION 14.2.2.A OF THE TOWN OF LEESBURG ZONING ORDINANCE. THE DEVELOPMENT WILL PROVIDE STORMWATER BMP IN ACCORDANCE WITH DCSM REQUIREMENTS.
- THE PROPOSED USE IS SINGLE FAMILY ATTACHED RESIDENTIAL, MULTI-FAMILY RESIDENTIAL AND COMMERCIAL. THE EXISTING ZONE IS PRN PER THE PROPOSED ZONING PLAN.
- TOPOGRAPHIC INFORMATION WAS TAKEN FROM AN ALTA/ACSM LAND TITLE SURVEY PREPARED BY BOWMAN CONSULTING GROUP ON 12/28/2011 AND REVISED 9/17/2012. THE CONTOUR INTERVAL IS 1 FOOT. GRID COORDINATES SHOWN ARE BASED ON VIRGINIA STATE PLANE COORDINATE, NORTH ZONE NAD 1983. THERE ARE NO STEEP SLOPES (MODERATE OR VERY) LOCATED ON THE PROPERTY PER LOUDOUN COUNTY GIS DATA.
- AREAS OF MINOR AND MAJOR FLOODPLAIN ARE LOCATED ON THE PROPERTY PER FLF 2010-0003 PREPARED BY THE ENGINEERING GROUPE AND APPROVED 09/09/2011. A FLOODPLAIN STUDY AND ALTERATION WILL BE REQUIRED PRIOR TO SITE PLAN APPROVAL TO PERMIT DEVELOPMENT OF THE SITE.
- SOILS INFORMATION SHOWN IS FROM LOUDOUN COUNTY SOILS OVERLAY MAPS.
- THIS PROJECT IS LOCATED WITHIN 1 MILE OF THE 60 LDN CONTOUR FOR LEESBURG EXECUTIVE AIRPORT. PORTIONS OF THE SITE ARE SUBJECT TO THE AIRPORT OVERLAY DISTRICT (A-I) REGULATIONS FOUND IN SECTION 7.7 OF THE TOWN OF LEESBURG ZONING ORDINANCE.
- THE SITE WILL BE SUPPLIED WITH PUBLIC WATER AND SANITARY SEWER BY EXTENSION OF EXISTING SYSTEMS. PROPOSED UTILITY LOCATIONS ARE CONCEPTUAL AND SUBJECT TO FINAL ENGINEERING.
- ALL UTILITY DISTRIBUTION LINES SHALL BE PLACED UNDERGROUND.
- FIRE HYDRANT INSTALLATION/COVERAGE SHALL BE PROVIDED IN ACCORDANCE WITH THE TOWN OF LEESBURG DESIGN AND CONSTRUCTION STANDARDS MANUAL (DCSM).
- BUFFER YARDS AND LANDSCAPING SHALL BE COMPLETED IN ACCORDANCE WITH ARTICLE 12 OF THE TOWN OF LEESBURG ZONING ORDINANCE OR AS OTHERWISE MODIFIED WITH THIS APPLICATION.
- ALL STORMWATER RUNOFF CONTROLS WILL BE PROVIDED ON SITE PER APPLICABLE STATE AND LOCAL STANDARDS. SEE SHEETS 8 AND 9 FOR PRELIMINARY SWM AND BMP PLANS, RESPECTIVELY. PROPOSED STORM SEWER LOCATIONS ARE CONCEPTUAL AND SUBJECT TO FINAL ENGINEERING.
- TREE PLANTING AND REPLACEMENT SHALL CONFORM TO THE STANDARDS OF ARTICLE 12 OF THE TOWN OF LEESBURG ZONING ORDINANCE AND ARTICLE 8 OF THE DCSM.
- PROPOSED IMPROVEMENTS TO HARRISON STREET SHALL CONFORM TO THE CURRENT TOWN OF LEESBURG AND VIRGINIA DEPARTMENT OF TRANSPORTATION STANDARDS AND SPECIFICATIONS.
- ALL PROPOSED SUBDIVISION STREETS SHOWN HERON SHALL BE PRIVATELY OWNED AND MAINTAINED.
- ALL SUBDIVISION STREETS SHALL CONFORM TO THE REQUIREMENTS OF ARTICLE 7 OF THE DCSM OR AS OTHERWISE MODIFIED WITH THIS APPLICATION.
- SITE LIGHTING WILL BE PROVIDED IN ACCORDANCE WITH TOWN OF LEESBURG ZONING ORDINANCE ARTICLE 12.11.
- NO KNOWN EXISTING WELLS OR SEPTIC SYSTEMS ARE LOCATED ON THE SITE. ANY DISCOVERED THROUGH THE COURSE OF DEVELOPMENT WILL BE ABANDONED IN ACCORDANCE WITH THE HEALTH DEPARTMENT STANDARDS IN PLACE AT THE TIME OF ABANDONMENT.
- ALL EXISTING STRUCTURES ON SITE WILL BE REMOVED UNLESS OTHERWISE NOTED.
- NO FEDERAL OR STATE PERMITS OR CONDITIONS DIRECTLY LIMIT DEVELOPMENT OF THIS PROPERTY.
- BASED ON AVAILABLE MAPS AND RECORDS THERE ARE NO KNOWN ENVIRONMENTAL OR HISTORIC FEATURES THAT WILL REQUIRE PROTECTION LOCATED ON THE SUBJECT PROPERTIES.
- BASED ON AVAILABLE MAPS AND RECORDS, THERE ARE NO KNOWN BURIAL SITES ON THE SUBJECT PROPERTIES.
- A TRAFFIC IMPACT ANALYSIS WAS PERFORMED BY BOWMAN CONSULTING, DATED 11/1/12.
- DEVELOPMENT OF THE PROPERTY SHALL BE IN SUBSTANTIAL CONFORMANCE WITH THIS CONCEPT PLAN WHICH SHALL CONTROL THE USE, LAYOUT AND CONFIGURATION OF THE PROPERTY, WITH REASONABLE ALLOWANCES TO BE MADE FOR ENGINEERING AND DESIGN ALTERATION TO MEET TOWN ZONING, SUBDIVISION AND LAND DEVELOPMENT REGULATIONS.

CRESCENT PLACE

TLZM 2012-0003

ZONING CONCEPT PLAN AMENDMENT AND PROFFER AMENDMENT

TOWN OF LEESBURG LOUDOUN COUNTY, VIRGINIA

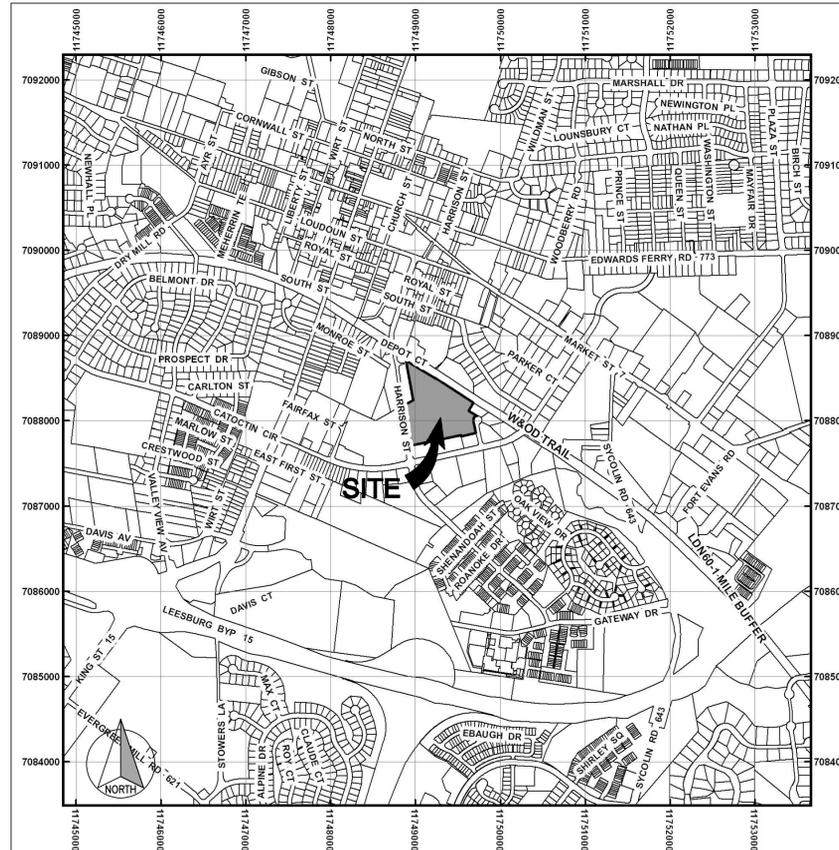

VICINITY MAP

1" = 1000'

ZONING MODIFICATIONS:

SEC. 8.3.2	THE APPLICANT REQUESTS A MODIFICATION OF THE LOT AREA, LOT WIDTH, AND AVERAGE LOT SIZE AS SHOWN ON THE LOT SIZE TABLE FOR SINGLE-FAMILY ATTACHED (TOWNHOUSE). THE APPLICANT PROPOSES A MINIMUM LOT SIZE OF 800 SF, A MINIMUM LOT WIDTH OF 16 FEET AND A MINIMUM AVERAGE LOT SIZE OF 1,000 SF.
SEC. 11.3	THE APPLICANT REQUESTS A MODIFICATION OF THE PARKING STANDARDS TABLE. SINGLE FAMILY ATTACHED AND MULTI-FAMILY RESIDENTIAL PARKING WILL BE PROVIDED AT 2.5 SPACES PER UNIT TO INCLUDE FULL CREDIT FOR ALL GARAGE AND DRIVEWAY SPACES. COMMERCIAL PARKING WILL BE PROVIDED AT THE GENERAL RETAIL SALES (INC. EATING ESTABLISHMENTS) RATE.
SEC. 11.9	THE APPLICANT REQUESTS A MODIFICATION OF THE REQUIRED OFF-STREET LOADING SPACES. THE APPLICANT WILL PROVIDE ONE FULL SIZE LOADING SPACE TO SHARE BETWEEN FUTURE COMMERCIAL USES.
SEC. 12.3.1.E	THE APPLICANT REQUESTS A MODIFICATION OF THE 20-YEAR TREE CANOPY COVERAGE REQUIREMENTS. THE APPLICANT PROPOSES TO ELIMINATE THE 2.5% & 3,000 SF CANOPY COVERAGE REQUIREMENT FOR PLATTED LOTS PER SEC. 8.2.2.E.
SEC. 12.8.5.C & 12.8.6.D	THE APPLICANT REQUESTS A MODIFICATION OF THE SCREENING AND BUFFER YARD REQUIREMENTS. THE APPLICANT PROPOSES BUFFERS AS SHOWN ON THE CONCEPTUAL LANDSCAPE PLAN. PROPOSED SIDEWALKS AND RETAINING WALLS MAY BE LOCATED WITHIN BUFFERS AS WELL AS OTHER PERMITTED ENCROACHMENTS AS SHOWN ON THE LANDSCAPE PLAN.
SEC. 14.2.1.B	THE APPLICANT REQUESTS A MODIFICATION OF THE CREEK VALLEY BUFFER. THE APPLICANT PROPOSES TO REDUCE THE SETBACK FROM 150 FEET AS NECESSARY TO PROVIDE IMPROVEMENTS TO HARRISON STREET AND DEVELOP THE SITE AS SHOWN ON THE CONCEPT DEVELOPMENT PLAN.
SEC. 10.4.5.C.4&5	THE APPLICANT REQUESTS A MODIFICATION OF THE MINIMUM YARD REQUIREMENTS FOR EXTENSIONS PERMITTED INTO REQUIRED YARDS TO PERMIT FRONT STOOPS AND REAR DECKS MORE THAN 3- FEET ABOVE GRADE TO EXTEND TO THE PROPERTY LINE.
SEC. 11.6.2.C.	THE APPLICANT REQUESTS A MODIFICATION OF THE MINIMUM AISLE WIDTH REQUIREMENT. THE APPLICANT PROPOSES TO REDUCE THE AISLE WIDTH FOR THE ROPC2 TRAVELWAY TO 20' AS DEPICTED ON THE CORRESPONDING TYPICAL SECTION ON SHEET 5.

DCSM MODIFICATIONS:

SEC. 7-361.3	THE APPLICANT REQUESTS A MODIFICATION OF THE SPACING OF ENTRANCES ON THE PUBLIC RIGHT OF WAY TO PERMIT TWO ENTRANCES ONTO INDUSTRIAL COURT WITH A SEPARATION OF 104.5 FEET.
--------------	---

ZONING ORDINANCE STANDARDS

PRN - PLANNED RESIDENTIAL NEIGHBORHOOD
(AS PROPOSED WITH THIS APPLICATION PER ZO. SEC. 8.4.6)

	UTILITY (AT&T)	COMMERCIAL (LIVE/WORK)	MULTI-FAMILY (2/2)	SINGLE FAMILY ATTACHED
MINIMUM LOT AREA:	N/A	10,000 SF	10,000 SF	800 SF (MODIFICATION REQUESTED)
AVERAGE LOT SIZE:	N/A	N/A	N/A	1,000 SF MIN. (MODIFICATION REQUESTED)
MINIMUM LOT WIDTH:	N/A	75 FEET	75 FEET	16 FEET (MODIFICATION REQUESTED)
MAX. FLOOR AREA RATIO:	NONE	NONE	N/A	N/A
MAX. BUILDING HEIGHT:	40 FEET	56 FEET	56 FEET	50 FEET
MIN. YARDS/SETBACKS (MEASURED TO LOT LINE, ROW, OR VEHICULAR ACCESS EASEMENT.)	FRONT: 20 FEET SIDE: 4 FEET, 0 FEET COMMON WALLS REAR: 5 FEET	15 FEET 5 FEET, 0 FEET COMMON WALLS, 1 FOOT FOR BUILDING "C" 18 FEET 4 FEET FOR BUILDING "C"	4 FEET 5 FEET 18 FEET	3.5 FEET (MODIFICATION REQUESTED) 5 FEET, 0 FEET COMMON WALLS 1 FOOT WHEN ADJACENT TO SIDEWALK 4 FEET 0 FEET COMMON WALLS

OWNER
LEESBURG ACQUISITION PARTNERS LLC
2553 DULLES VIEW DRIVE, SUITE 400
HERNDON, VA 20171
ATT: MR. LEONARD S. "HOBIE" MITCHEL

SIGNATURE _____ DATE _____

OWNER

AT&T CORP.
P.O. BOX 7207
BEDMINSTER, NJ 07921 7207

SIGNATURE _____ DATE _____

APPLICANT
LEESBURG ACQUISITION PARTNERS LLC
2553 DULLES VIEW DRIVE, SUITE 400
HERNDON, VA 20171
ATT: MR. LEONARD S. "HOBIE" MITCHEL

SIGNATURE _____ DATE _____

SHEET INDEX

- COVER SHEET
- EXISTING CONDITIONS PLAN
- CONCEPT PLAN
- LANDSCAPE PLAN
- TYPICAL SECTIONS AND DETAILS
- TYPICAL SECTIONS AND DETAILS
- GRADING PLAN
- UTILITY PLAN
- PRELIMINARY SWM PLAN
- PRELIMINARY BMP PLAN
- LIGHTING PLAN
- LIGHTING DETAILS
- PHASING PLAN
- ILLUSTRATIVE PLAN
- PLAN OVERLAY EXHIBIT
- AUTO-TURN EXHIBIT
- OPEN SPACE PLAN
- OPEN SPACE AMENITIES PLAN
- FENCE DESIGN ILLUSTRATIVE EXHIBIT
- SIGHT DISTANCE
- SIGHT DISTANCE
- SIGHT DISTANCE
- ZONING PLAT
- PARKING EXHIBIT



Bowman Consulting Group, Ltd.
101 South Street, S. E.
Leesburg, Virginia 20175
Phone: (703) 443-2400
Fax: (703) 443-2405
www.bowmanconsulting.com
© Bowman Consulting Group, Ltd.

COVER SHEET
CRESCENT PLACE
ZONING CONCEPT PLAN & PROFFER AMENDMENT
TLZM-2012-0003
LOUDOUN COUNTY, VIRGINIA

DATE	DESCRIPTION
11/20/12	PER CHECKLIST COMMENTS
3/28/13	PER 1ST SUB. COMMENTS
6/14/13	PER 2ND SUB. COMMENTS
8/14/13	PER PC COMMENTS
9/18/13	PER PC COMMENTS
10/07/13	PER PC COMMENTS
10/18/13	PER PC COMMENTS
11/01/13	PER TC COMMENTS


DATE	DESCRIPTION	
BDR	JAE	CM
DESIGN	DRAWN	CHKD
SCALE	H: AS SHOWN	V:
JOB No.	5371-01-003	
DATE	NOVEMBER 5, 2012	
FILE No.	5371-D-ZP-001	

SHEET 1 of 24

Doc file name: \\c:\pds\new_projects\5371 - Crescent Circle Ind. Sub-Station, ZP-A Tower.dwg

ADJACENT OWNER ADDRESS

Pin	Owner	Owner Address	Owner Address
231195137000	NORTHERN VA REGIONAL PARK AUTHORITY	5400 OX RD	FAIRFAX STATION VA22039-1052
231187370000	LEESBURG, TOWN OF	PO BOX 88	LEESBURG VA20178-0088
231197438000	BANNER GLASS INC	PO BOX 8340	SILVER SPRING MD20907-8340
231185606000	VIRGINIA VILLAGE II LLC	PO BOX 1231	LEESBURG VA20177-1231
232490793000	MIDDLEBURG BANK, THE	PO BOX 5	MIDDLEBURG VA20118-0005
232493195000	MIDDLEBURG BANK, THE	PO BOX 5	MIDDLEBURG VA20118-0005
231196405000	REINHARDT LLC	301A INDUSTRIAL CT SE	LEESBURG VA20175
231198727000	L & J PROPERTIES OF LOUDOUN LLC	925 EDWARDS FERRY RD NE	LEESBURG VA20176-3301
231198510001	L & J PROPERTIES OF LOUDOUN LLC	925 EDWARDS FERRY RD NE	LEESBURG VA20176-3301
231198510002	L & J PROPERTIES OF LOUDOUN LLC	925 EDWARDS FERRY RD NE	LEESBURG VA20176-3301
231198510003	OSTERHOUDT, DENISE & CHAD	249 MEADOWS LN NE	LEESBURG VA20176-4449
231198510004	L & J PROPERTIES OF LOUDOUN LLC	925 EDWARDS FERRY RD NE	LEESBURG VA20176-3301
231198510005	LGI INVESTMENTS LLC	302 INDUSTRIAL CT SE STE F	LEESBURG VA20175-3731
231198510006	LGI INVESTMENTS LLC	302 INDUSTRIAL CT SE STE F	LEESBURG VA20175-3731
231198510007	LGI INVESTMENTS LLC	302 INDUSTRIAL CT SE STE F	LEESBURG VA20175-3731
231198510008	HESSEIN, MOSTAFA M. & CAROLINA LUCCI	302 A1 INDUSTRIAL CT SE STE F	LEESBURG VA20175-0000
231198510009	HESSEIN, MOSTAFA M. & CAROLINA LUCCI	302 A1 INDUSTRIAL CT SE STE F	LEESBURG VA20175-0000

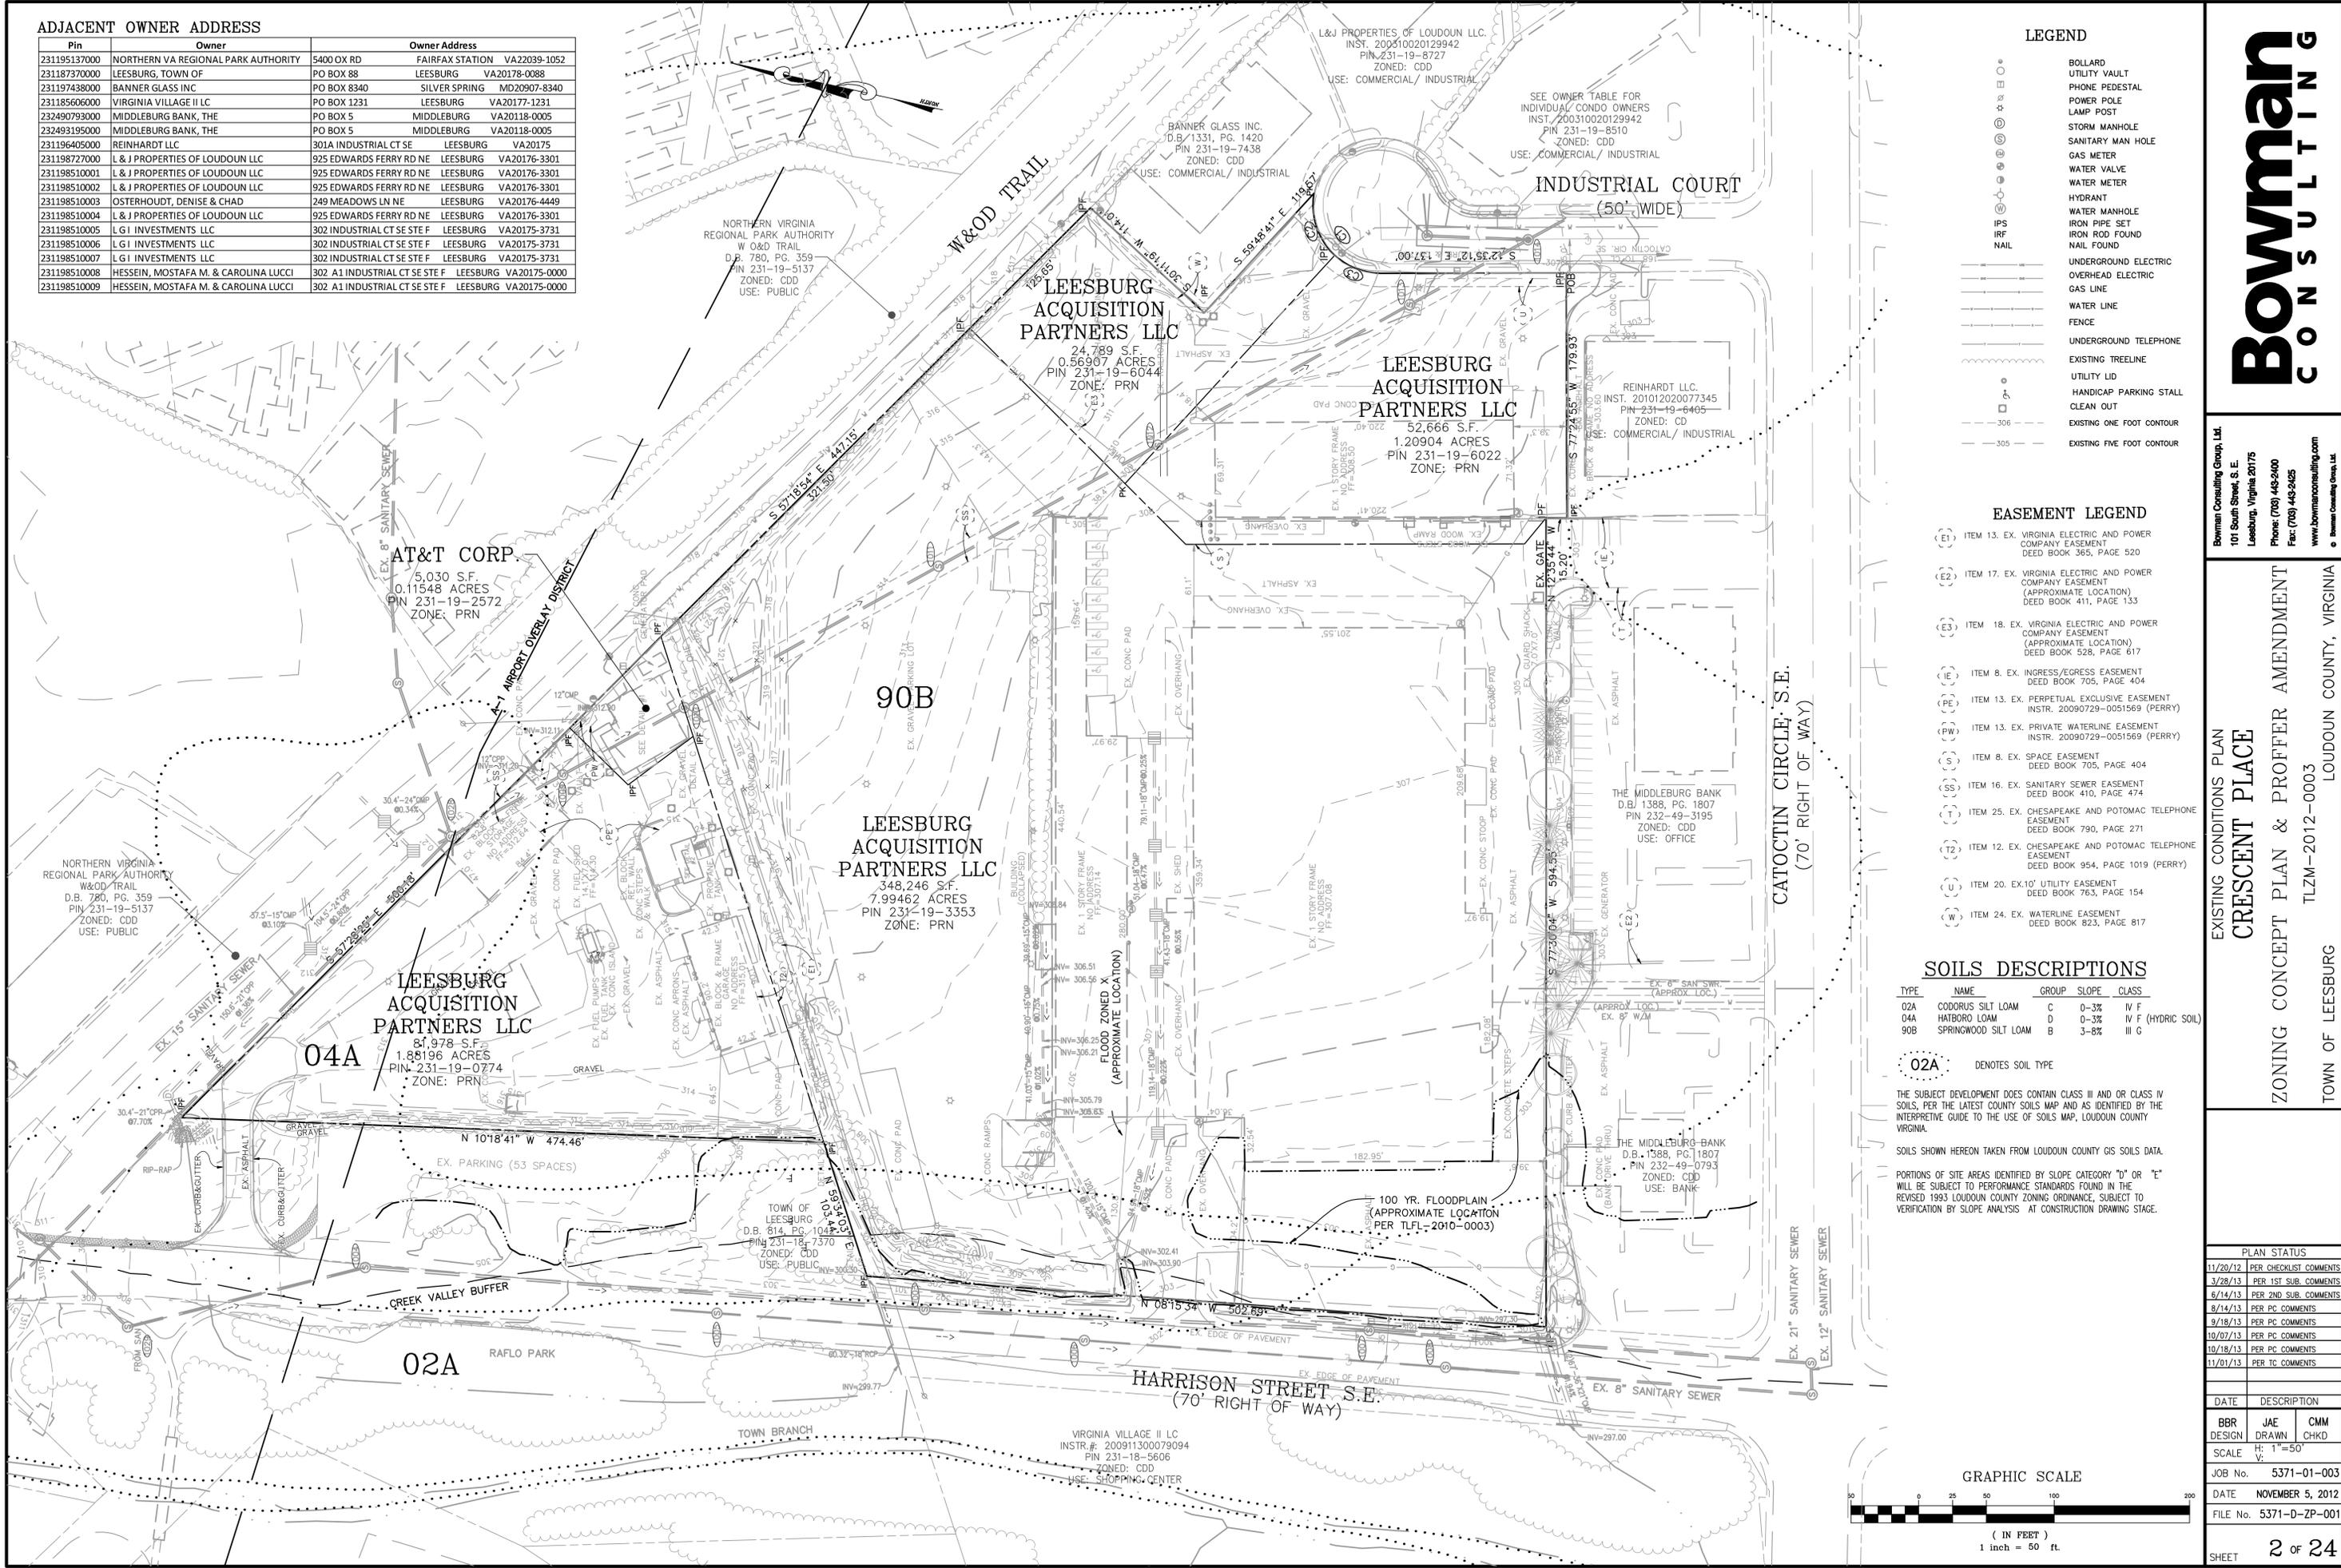

LEGEND

○	BOLLARD
○	UTILITY VAULT
○	PHONE PEDESTAL
○	POWER POLE
○	LAMP POST
○	STORM MANHOLE
○	SANITARY MAN HOLE
○	GAS METER
○	WATER VALVE
○	WATER METER
○	HYDRANT
○	WATER MANHOLE
○	IRON PIPE SET
○	IRON ROD FOUND
○	NAIL FOUND
○	UNDERGROUND ELECTRIC
○	OVERHEAD ELECTRIC
○	GAS LINE
○	WATER LINE
○	FENCE
○	UNDERGROUND TELEPHONE
○	EXISTING TREELINE
○	UTILITY LID
○	HANDICAP PARKING STALL
○	CLEAN OUT
○	EXISTING ONE FOOT CONTOUR
○	EXISTING FIVE FOOT CONTOUR

EASEMENT LEGEND

(E1)	ITEM 13. EX. VIRGINIA ELECTRIC AND POWER COMPANY EASEMENT DEED BOOK 365, PAGE 520
(E2)	ITEM 17. EX. VIRGINIA ELECTRIC AND POWER COMPANY EASEMENT (APPROXIMATE LOCATION) DEED BOOK 411, PAGE 153
(E3)	ITEM 18. EX. VIRGINIA ELECTRIC AND POWER COMPANY EASEMENT (APPROXIMATE LOCATION) DEED BOOK 528, PAGE 617
(E)	ITEM 8. EX. INGRESS/EGRESS EASEMENT DEED BOOK 705, PAGE 404
(PE)	ITEM 13. EX. PERPETUAL EXCLUSIVE EASEMENT INSTR. 20090729-0051569 (PERRY)
(PW)	ITEM 13. EX. PRIVATE WATERLINE EASEMENT INSTR. 20090729-0051569 (PERRY)
(S)	ITEM 8. EX. SPACE EASEMENT DEED BOOK 705, PAGE 404
(SS)	ITEM 16. EX. SANITARY SEWER EASEMENT DEED BOOK 410, PAGE 474
(T)	ITEM 25. EX. CHESAPEAKE AND POTOMAC TELEPHONE EASEMENT DEED BOOK 790, PAGE 271
(T2)	ITEM 12. EX. CHESAPEAKE AND POTOMAC TELEPHONE EASEMENT DEED BOOK 954, PAGE 1019 (PERRY)
(U)	ITEM 20. EX.10' UTILITY EASEMENT DEED BOOK 763, PAGE 154
(W)	ITEM 24. EX. WATERLINE EASEMENT DEED BOOK 823, PAGE 817

SOILS DESCRIPTIONS


TYPE	NAME	GROUP	SLOPE	CLASS
02A	CODORUS SILT LOAM	C	0-3%	IV F
04A	HARBORO LOAM	D	0-3%	IV F (HYDRIC SOIL)
90B	SPRINGWOOD SILT LOAM	B	3-8%	III G

02A DENOTES SOIL TYPE

THE SUBJECT DEVELOPMENT DOES CONTAIN CLASS III AND OR CLASS IV SOILS, PER THE LATEST COUNTY SOILS MAP AND AS IDENTIFIED BY THE INTERPRETIVE GUIDE TO THE USE OF SOILS MAP, LOUDOUN COUNTY VIRGINIA.

SOILS SHOWN HEREON TAKEN FROM LOUDOUN COUNTY GIS SOILS DATA.

PORTIONS OF SITE AREAS IDENTIFIED BY SLOPE CATEGORY "D" OR "E" WILL BE SUBJECT TO PERFORMANCE STANDARDS FOUND IN THE REVERSED 1993 LOUDOUN COUNTY ZONING ORDINANCE, SUBJECT TO VERIFICATION BY SLOPE ANALYSIS AT CONSTRUCTION DRAWING STAGE.

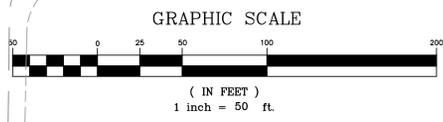

Bowman CONSULTING

Bowman Consulting Group, Ltd.
101 South Street, S. E.
Leesburg, Virginia 20175
Phone: (703) 443-2400
Fax: (703) 443-2405
www.bowmanconsulting.com

EXISTING CONDITIONS PLAN
CRESCENT PLACE
ZONING CONCEPT PLAN & PROFFER AMENDMENT
TLZM-2012-0003 LOUDOUN COUNTY, VIRGINIA
TOWN OF LEESBURG

DATE	DESCRIPTION
11/20/12	PER CHECKLIST COMMENTS
3/28/13	PER 1ST SUB. COMMENTS
6/14/13	PER 2ND SUB. COMMENTS
8/14/13	PER PC COMMENTS
9/18/13	PER PC COMMENTS
10/07/13	PER PC COMMENTS
10/18/13	PER PC COMMENTS
11/01/13	PER TC COMMENTS

DATE	DESCRIPTION
BBR DESIGN	JAE DRAWN
	CHM CHKD
SCALE	H: 1"=50'
JOB No.	5371-01-003
DATE	NOVEMBER 5, 2012
FILE No.	5371-D-ZP-001

SHEET **2** OF **24**

SITE TABULATIONS

SITE TABULATIONS

Total Site Area: 11.77 AC

Existing Zoning: PRN (11.65 AC) CDD (0.12AC)

Proposed Zoning: PRN

Proposed Density: 18.86 DU/ACRE (222 Units / 11.77 Acres)

Proposed Use:

Ex. Utility:	2,623 SF
Proposed Utility:	2,230 SF
Total Utility:	4,853 SF
Commercial (First Level of Live/Work)	20,000 SF
Residential:	
Townhomes:	142 Units
Multi-Family (2 over 2):	60 Units
Multi-Family (Live / Work):	20 Units
Total Units (See Note 1 on this Sheet)	222 Units

Public Common Open Space Required (Infill PRN Site): 15% (1.77 Acres)

Total Public Common Open Space Provided: >15% (1.94 Acres)

Pedestrian Central Plaza/Green (Near Building Q):	0.30 Acres
Boulevard Open Space:	0.20 Acres
Residential Common Green (Near Buildings Y-BB):	0.21 Acres
Community Promenade (Near Building A):	0.32 Acres
Linear Pocket Park (Near Building R,S and T):	0.19 Acres
Traillfront Promenade (Near Building C):	0.04 Acres
Perimeter Open Space:	0.68 Acres

Parking and Loading Requirements:

Utility:	4,853 SF
(1.0 per employee, plus 1.0 per company vehicle)	3 Spaces
Retail:	20,000 SF
Lower level of Live/ Work:	90 Spaces
(1.0 per 200 square feet gross floor area for the first 10,000 square feet, plus 4.0 per each additional 1,000 square feet of gross floor area.)	

Residential:

Single Family Attached (Townhomes) & Multi-Family (2 over 2 & Live/Work)	555 Spaces
Minimum Required Parking (222 Units @ 2.5 spaces per unit):	555 Spaces
Total Parking Spaces Required:	645 Spaces




Provided Parking On-Site(See Mod. 11.3 on Sheet 1):

Garage & Driveway Spaces:	591 Spaces
Internal Private Travelway, RCPC & Parking Lot Spaces:	473 Spaces
Utility Spaces:	115 Spaces
Utility Spaces:	3 Spaces
Provided Parking Off-Site:	113 Spaces
Harrison Street:	40 Spaces
Town Parking Lot:	73 Spaces

NOTES

1. THE ULTIMATE NUMBER OF SINGLE FAMILY ATTACHED (TOWNHOUSE) AND MULTI-FAMILY (2 OVER 2) UNITS MAY VARY AS LONG AS THE UNIT TYPE MAXIMUM IS NOT EXCEEDED AND NO MORE THAN 222 UNITS ARE DEVELOPED ON THE SITE.
2. BUILDING LABELS ARE FOR REFERENCE PURPOSES ONLY AND DO NOT INDICATE PROJECT PHASING.
3. PROPOSED RETAINING WALLS SHALL INCORPORATE ORNAMENTAL METAL FENCES ON TOP OF THE WALL WHEN REQUIRED DUE TO HEIGHT.
4. RESIDENTIAL COMMON PARKING COURTS (RCPC) WILL BE PROVIDED PURSUANT TO DCSM SECTION 7-370.1A & 1B.
5. ALL PEDESTRIAN CROSSINGS WITHIN THE R.O.W. SHALL BE SYNTHETIC ASPHALT OR A SIMILAR TOWN APPROVED MATERIAL.

 LEGEND

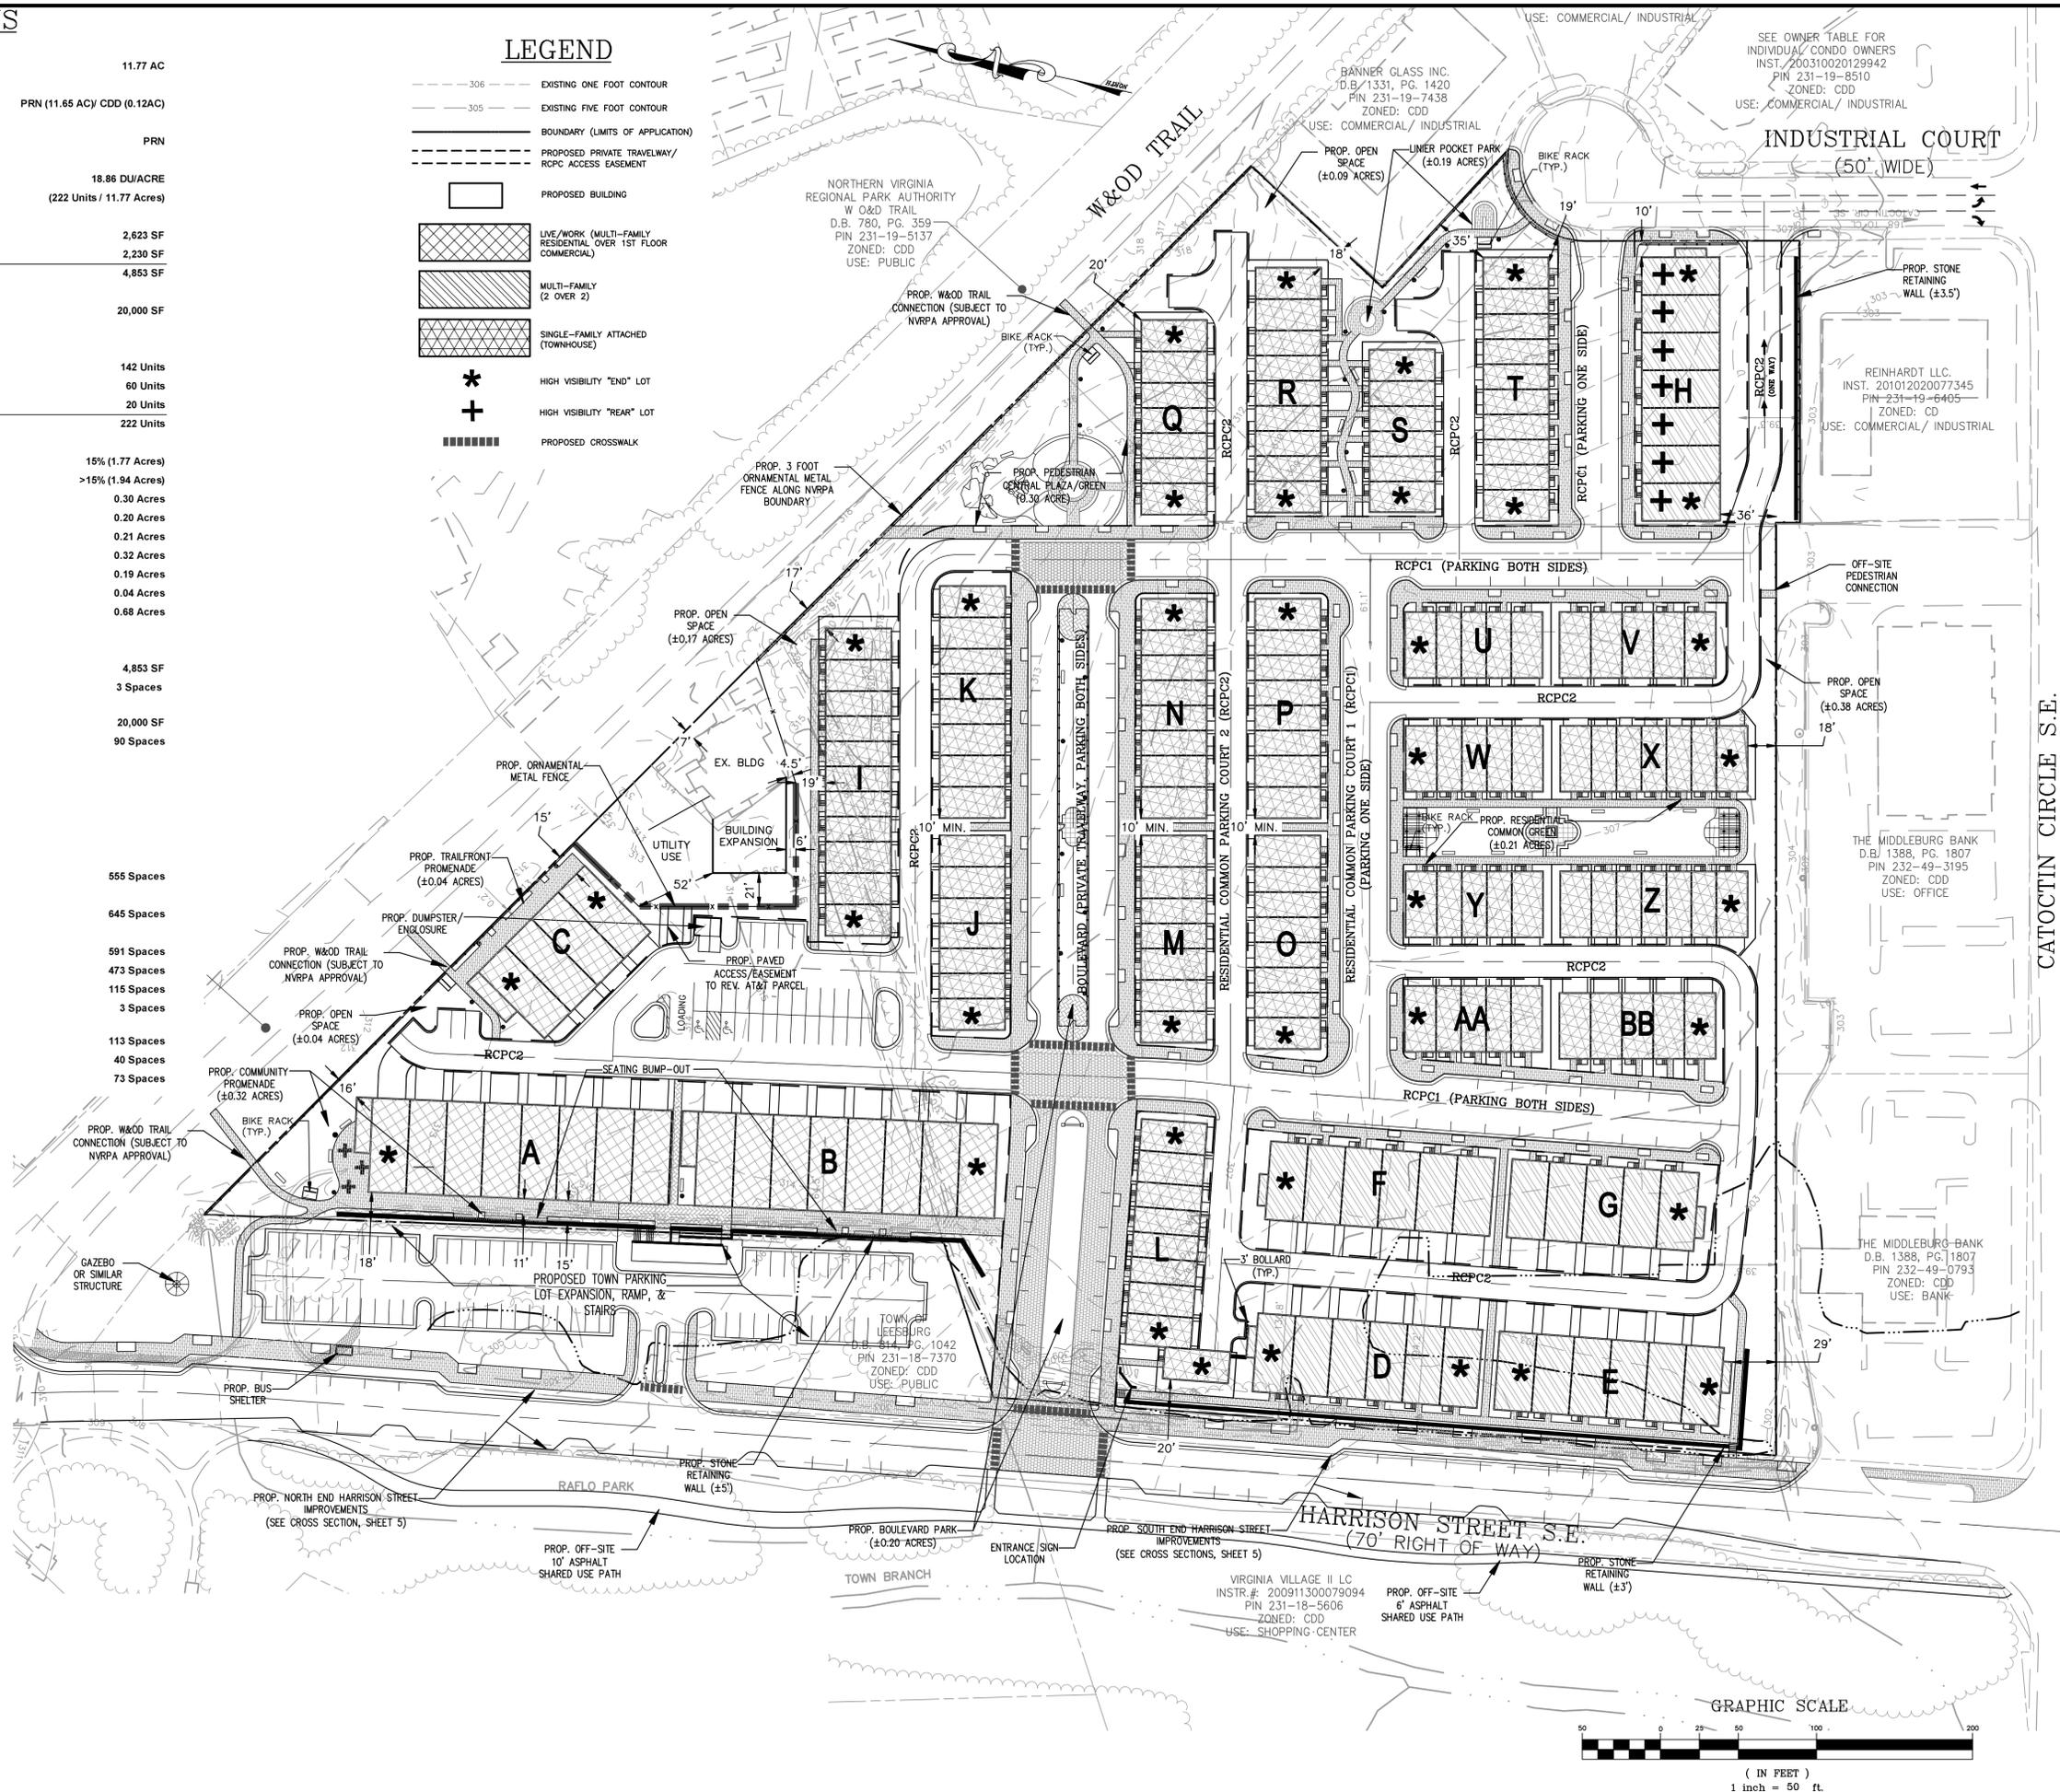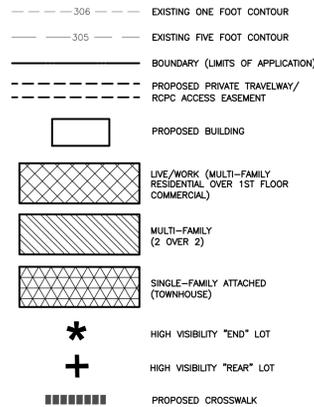

Bowman

CONSULTING

Bowman Consulting Group, Ltd.
101 South Street, S.E.
Leesburg, Virginia 20175
Phone: (703) 443-2400
Fax: (703) 443-2405
www.bowmanconsulting.com
© Bowman Consulting Group, Ltd.

CONCEPT PLAN
CRESCENT PLACE
ZONING CONCEPT PLAN & PROFFER AMENDMENT
TLZM-2012-0003 LOUDOUN COUNTY, VIRGINIA

DATE	DESCRIPTION
11/20/12	PER CHECKLIST COMMENTS
3/28/13	PER 1ST SUB. COMMENTS
6/14/13	PER 2ND SUB. COMMENTS
8/14/13	PER PC COMMENTS
9/18/13	PER PC COMMENTS
10/07/13	PER PC COMMENTS
10/18/13	PER PC COMMENTS
11/01/13	PER TC COMMENTS

DATE	DESCRIPTION	BY	CHKD
	DESIGN	JAE	CHM
	DRAWN	JAE	CHM

SCALE: H: 1"=50'
V: 1"=50'

JOB No. 5371-01-003
DATE NOVEMBER 5, 2012
FILE No. 5371-D-ZP-001

SHEET 3 of 24

LANDSCAPE TABULATIONS

(SEC. 12.8) BUFFERS AND SCREENING:

LANDSDOWNE ACQUISITIONS PROPERTY BUFFER CALCULATIONS										
Buffer	Yard	Length	Adjacent Ex. Buffer	Width	Area	Plantings Ratio	Plantings	Width	Proposed/Provided	Remarks
A to B	S-2 RESIDENTIAL (Rc) TO PUBLIC PARKING (Ia)	580'	0'	Req. 25.0'	14500 SF	1 Large Canopy / 1000 SF 1 Medium Canopy / 1000 SF 0 Understory 1 Evergreen / 500 SF 1 Shrubs / 100 SF	15 Large Canopy 15 Medium Canopy 0 Understory 29 Evergreen 145 Shrubs	3' to include retaining wall and fence (Plantings provided on Town parking lot property)	0 Large Canopy 0 Medium Canopy 4 Understory 0 Evergreen 48 Shrubs	Modification Requested (See Sheet 1)
B to C	S-2 RESIDENTIAL (Rc) TO W&OD TRAIL (Ia)	335'	0'	Req. 25.0'	8375 SF	1 Large Canopy / 1000 SF 1 Medium Canopy / 1000 SF 0 Understory 1 Evergreen / 500 SF 1 Shrubs / 100 SF	8 Large Canopy 8 Medium Canopy 0 Understory 17 Evergreen 84 Shrubs	0' Min./6' Max. to include fence	0 Large Canopy 0 Medium Canopy 11 Understory 12 Evergreen 67 Shrubs	Modification Requested (See Sheet 1)
D to E	S-2 RESIDENTIAL (Rc) TO W&OD TRAIL (Ia)	450'	0'	Req. 25.0'	11250 SF	1 Large Canopy / 1000 SF 1 Medium Canopy / 1000 SF 0 Understory 1 Evergreen / 500 SF 1 Shrubs / 100 SF	11 Large Canopy 11 Medium Canopy 0 Understory 23 Evergreen 113 Shrubs	5' Min./15' Max. to include fence	3 Large Canopy 5 Medium Canopy 16 Understory 6 Evergreen 82 Shrubs	Modification Requested (See Sheet 1)
E to F	S-3 RESIDENTIAL (Rc) TO INDUSTRIAL WOODSHOP STORAGE (Ia)	230'	0'	Req. 75.0'	17250 SF	1 Large Canopy / 1000 SF 1 Medium Canopy / 1000 SF 0 Understory 1 Evergreen / 500 SF 1 Shrubs / 100 SF	17 Large Canopy 17 Medium Canopy 0 Understory 35 Evergreen 173 Shrubs	5' Min./10' Max. to include fence	0 Large Canopy 0 Medium Canopy 10 Understory 10 Evergreen 35 Shrubs	Modification Requested (See Sheet 1)
G to H	S-3 RESIDENTIAL (Rc) TO OFFICER/RETAIL (Ca)	180'	0'	Req. 25.0'	4500 SF	1 Large Canopy / 1000 SF 1 Medium Canopy / 1000 SF 1 Understory / 500 SF 1 Evergreen / 500 SF 1 Shrubs / 100 SF	3 Large Canopy 3 Medium Canopy 9 Understory 9 Evergreen 45 Shrubs	10' Min. to include fence, wall	3 Large Canopy 4 Medium Canopy 3 Understory 3 Evergreen 26 Shrubs	Modification Requested (See Sheet 1)
H to I	S-3 RESIDENTIAL (Rc) TO OFFICER/RETAIL (Cc)	350'	18'	Req. 50.0'	11200 SF	1 Large Canopy / 1000 SF 1 Medium Canopy / 1000 SF 1 Understory / 500 SF 1 Evergreen / 500 SF 1 Shrubs / 100 SF	18 Large Canopy 18 Medium Canopy 35 Understory 35 Evergreen 175 Shrubs	6' Min. to include fence	1 Large Canopy 0 Medium Canopy 3 Understory 3 Evergreen 37 Shrubs	Modification Requested (See Sheet 1)
I to J	S-3 RESIDENTIAL (Rc) TO OFFICER/RETAIL (Cc)	245'	10'	Req. 50.0'	9800 SF	1 Large Canopy / 1000 SF 1 Medium Canopy / 1000 SF 1 Understory / 500 SF 1 Evergreen / 500 SF 1 Shrubs / 100 SF	12 Large Canopy 12 Medium Canopy 25 Understory 25 Evergreen 123 Shrubs	0' Min./12' Max. to include fence (Some plantings are provided on adjacent property)	2 Large Canopy 0 Medium Canopy 4 Understory 4 Evergreen 20 Shrubs	Modification Requested (See Sheet 1)
C to K	S-3 RESIDENTIAL (Rc) TO INDUSTRIAL (Ia)	58'	0'	Req. 75.0'	4350 SF	1 Large Canopy / 1000 SF 1 Medium Canopy / 1000 SF 1 Understory / 500 SF 1 Evergreen / 500 SF 1 Shrubs / 100 SF	4 Large Canopy 4 Medium Canopy 9 Understory 9 Evergreen 44 Shrubs	5' Min. to include fence	0 Large Canopy 0 Medium Canopy 3 Understory 3 Evergreen 6 Shrubs	Modification Requested (See Sheet 1)
K to L	S-3 RESIDENTIAL (Rc) TO INDUSTRIAL (Ia)	100'	0'	Req. 75.0'	7500 SF	1 Large Canopy / 1000 SF 1 Medium Canopy / 1000 SF 1 Understory / 500 SF 1 Evergreen / 500 SF 1 Shrubs / 100 SF	8 Large Canopy 8 Medium Canopy 15 Understory 15 Evergreen 75 Shrubs	6' Min. to include fence	1 Large Canopy 1 Understory 1 Evergreen 14 Shrubs	Modification Requested (See Sheet 1)
L to D	S-3 RESIDENTIAL (Rc) TO INDUSTRIAL (Ia)	160'	0'	Req. 75.0'	12000 SF	1 Large Canopy / 1000 SF 1 Medium Canopy / 1000 SF 1 Understory / 500 SF 1 Evergreen / 500 SF 1 Shrubs / 100 SF	12 Large Canopy 12 Medium Canopy 24 Understory 24 Evergreen 120 Shrubs	4' Min. to include fence	0 Large Canopy 0 Medium Canopy 6 Understory 11 Evergreen 26 Shrubs	Modification Requested (See Sheet 1)

AT&T CORP. PROPERTY BUFFER CALCULATIONS										
Buffer	Yard	Length	Adjacent Ex. Buffer	Width	Area	Plantings Ratio	Plantings	Width	Proposed/Provided	Remarks
C to D	S-3 INDUSTRIAL (Ia) TO W&OD TRAIL (Ia)	165'	0'	Req. 75.0'	12375 SF	1 Large Canopy / 1000 SF 1 Medium Canopy / 1000 SF 1 Understory / 500 SF 1 Evergreen / 500 SF 1 Shrubs / 100 SF	12 Large Canopy 12 Medium Canopy 25 Understory 25 Evergreen 123 Shrubs	3' Min. to include fence	0 Large Canopy 0 Medium Canopy 1 Understory 6 Evergreen 15 Shrubs	Modification Requested (See Sheet 1)
C to K	S-3 INDUSTRIAL (Ia) TO RESIDENTIAL (Rc)	58'	0'	Req. 75.0'	4350 SF	1 Large Canopy / 1000 SF 1 Medium Canopy / 1000 SF 1 Understory / 500 SF 1 Evergreen / 500 SF 1 Shrubs / 100 SF	4 Large Canopy 4 Medium Canopy 9 Understory 9 Evergreen 44 Shrubs	15' Min. to include fence	0 Large Canopy 0 Medium Canopy 2 Understory 2 Evergreen 12 Shrubs	Modification Requested (See Sheet 1)
K to L	S-3 INDUSTRIAL (Ia) TO RESIDENTIAL (Rc)	100'	0'	Req. 75.0'	7500 SF	1 Large Canopy / 1000 SF 1 Medium Canopy / 1000 SF 1 Understory / 500 SF 1 Evergreen / 500 SF 1 Shrubs / 100 SF	8 Large Canopy 8 Medium Canopy 15 Understory 15 Evergreen 75 Shrubs	5' Min. to include fence	1 Large Canopy 0 Medium Canopy 2 Understory 2 Evergreen 9 Shrubs	Modification Requested (See Sheet 1)
L to D	S-3 INDUSTRIAL (Ia) TO RESIDENTIAL (Rc)	160'	0'	Req. 75.0'	12000 SF	1 Large Canopy / 1000 SF 1 Medium Canopy / 1000 SF 1 Understory / 500 SF 1 Evergreen / 500 SF 1 Shrubs / 100 SF	12 Large Canopy 12 Medium Canopy 24 Understory 24 Evergreen 120 Shrubs	0' Min. to include fence	0 Large Canopy 0 Medium Canopy 0 Understory 0 Evergreen 0 Shrubs	Modification Requested (See Sheet 1)

LANDSCAPE NOTES
 1. PROPOSED BUFFER PLANTINGS SHALL BE IN ACCORDANCE WITH ZO SECTION 12.9.6 OR AS MODIFIED AS PART OF THIS APPLICATION.
 2. PLANTING OF PROPOSED STREET TREES (PUBLIC & PRIVATE STREETS) WILL BE CONDUCTED UNDER THE SUPERVISION OF A CERTIFIED ARBORIST TO ENSURE PROPER PLANTING MATERIALS AND TECHNIQUE ARE USED AND ENSURE SURVIVABILITY OF TREES.
 3. UNDERSTORY TREES LOCATED ADJACENT TO OVERHEAD POWER LINES SHALL REMAIN IN GENERAL PROXIMITY TO THE LOCATIONS DEPICTED ON THIS SHEET.

(SEC. 12.6) INTERIOR PARKING LOT LANDSCAPING

Plantings Required (Sec.12.6.3)	5% of the gross parking lot area. AND 1 Tree per (16) Parking Spaces 3 Shrubs per (16) Parking Spaces
COMMERCIAL PARKING LOT (ON-SITE)	
Gross Parking Lot Area	12,000 SF
Required Interior Parking Lot Landscape Area	800 SF
Provided Interior Parking Lot Landscape Area	645 SF
Proposed Parking Spaces	33 Spaces
Required Plantings:	2 Trees 6 Shrubs
Provided Plantings:	2 Trees 6 Shrubs
TOWN PARKING LOT (OFF-SITE)	
Gross Parking Lot Area (Town Lot)	23,500 SF
Required Interior Parking Lot Landscape Area	1,175 SF
Provided Interior Parking Lot Landscape Area	1,200 SF
Proposed Parking Spaces	73 Spaces
Required Plantings:	5 Trees 14 Shrubs
Provided Plantings:	6 Trees 18 Shrubs

(SEC. 12.5) PERIMETER PARKING LOT LANDSCAPING - TOWN PARKING LOT

PERIMETER PARKING LOT LANDSCAPING: PLANTING REQUIREMENTS (OFF-SITE)	
Plantings Required (Parking lots adjacent to a public street Sec.12.5.3)	Shrub screen no greater than 4' spacing AND 1 Tree per 40' of Frontage
Min. Planting Width:	10'
LF of Parking Lot Frontage:	350'
Required Plantings:	9 Trees
Provided Plantings:	9 Trees



(SEC. 12.3) TWENTY-YEAR TREE CANOPY REQUIREMENTS:

SITE AREA:	512,709 SF
TOTAL REQUIRED 20-YEAR ON-SITE CANOPY COVERAGE:	51,271 SF (10%)
TOTAL PROVIDED 20-YEAR ON-SITE CANOPY COVERAGE:	51,540 SF (10%)

PLANT TYPE	CREDIT/TREE	QUANTITY	TOTAL CREDIT
LARGE CANOPY TREES	260 SF	45	11,700 SF
MEDIUM CANOPY TREES	185 SF	142	26,720 SF
UNDERSTORY TREES	110 SF	77	8,470 SF
LARGE EVERGREEN TREES	175 SF	24	4,200 SF
SMALL EVERGREEN TREES	25 SF	36	900 SF

LEGEND

- 306 - EXISTING ONE FOOT CONTOUR
- 305 - EXISTING FIVE FOOT CONTOUR
- BOUNDARY
- PROPOSED BUILDING
- PROPOSED MOLDED BRICK SIDEWALK AND LEADWALK
- PROPOSED SYNTHETIC ASPHALT
- PROPOSED CROSSWALK
- PROPOSED STREET LIGHT
- PROPOSED BOLLARD LIGHT
- PROPOSED STORM PIPE
- PROPOSED STORM INLET
- EXISTING SANITARY SEWER
- PROPOSED SANITARY SEWER
- EXISTING WATER LINE
- PROPOSED WATER LINE
- PROPOSED LARGE CANOPY TREE
- PROPOSED MEDIUM CANOPY TREE
- PROPOSED UNDERSTORY TREE
- PROPOSED SMALL EVERGREEN TREE
- PROPOSED LARGE EVERGREEN TREE
- PROPOSED SHRUBS

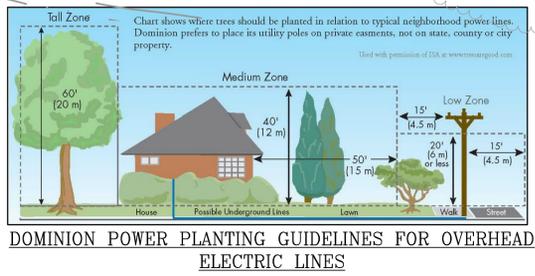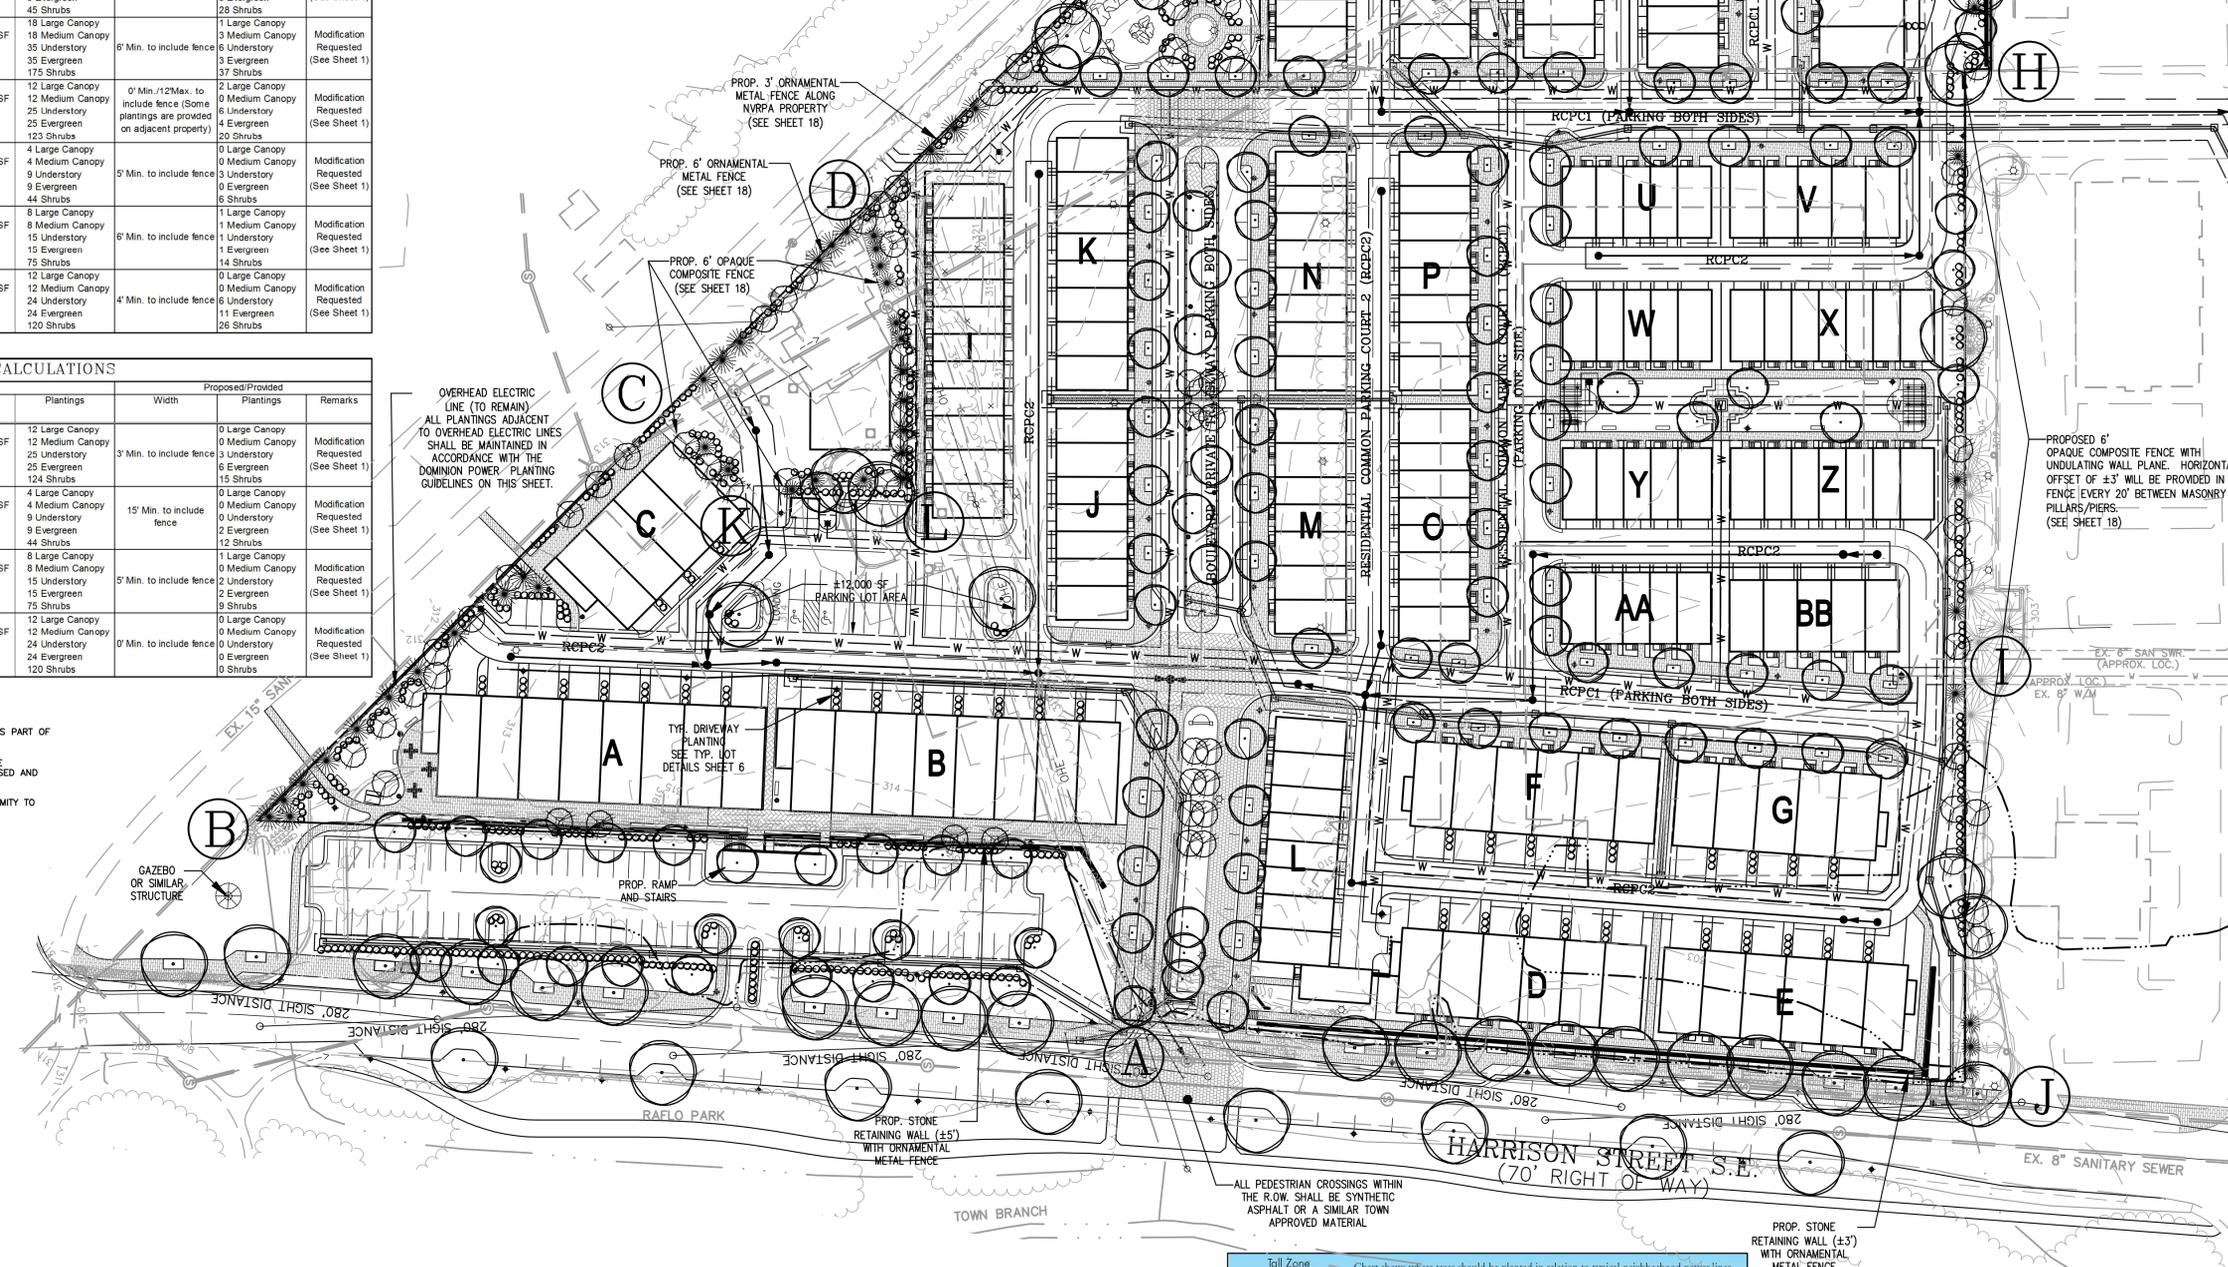

Bowman CONSULTING
 Bowman Consulting Group, Ltd.
 101 South Street, S.E.
 Leesburg, Virginia 20175
 Phone: (703) 443-2400
 Fax: (703) 443-2405
 www.bowmanconsulting.com

LANDSCAPE PLAN
CRESCENT PLACE
 ZONING CONCEPT PLAN & PROFFER AMENDMENT
 TLZM-2012-0003
 TOWN OF LEEBSBURG
 LOUDOUN COUNTY, VIRGINIA


DATE	DESCRIPTION
11/20/12	PER CHECKLIST COMMENTS
3/28/13	PER 1ST SUB. COMMENTS
6/14/13	PER 2ND SUB. COMMENTS
8/14/13	PER PC COMMENTS
9/18/13	PER PC COMMENTS
10/07/13	PER PC COMMENTS
10/18/13	PER PC COMMENTS
11/01/13	PER TC COMMENTS

DATE	DESCRIPTION
BBR DESIGN	JAE DRAWN
	CMM CHKD
SCALE	H: 1"=50'
JOB No.	5371-01-003
DATE	NOVEMBER 5, 2012
FILE No.	5371-D-ZP-001
SHEET	4 of 24




CROSS SECTION KEY MAP


SCALE: 1"=100'

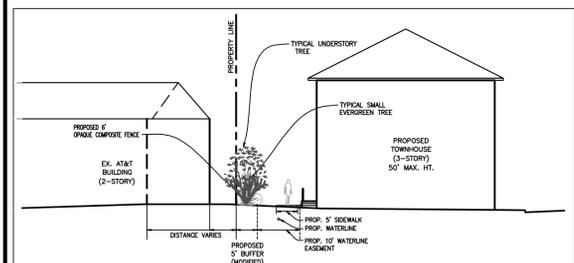


CROSS SECTION A-A
SCALE: 1"=20'

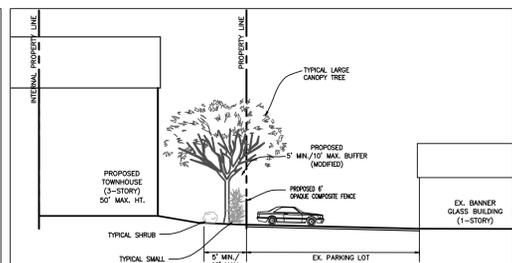


CROSS SECTION B-B
SCALE: 1"=20'

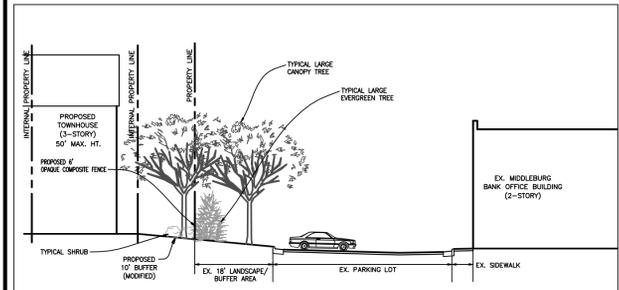

CROSS SECTION C-C
SCALE: 1"=20'

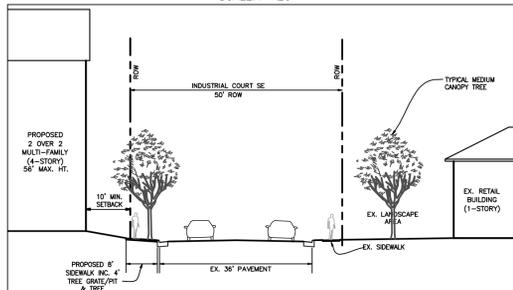


CROSS SECTION D-D
SCALE: 1"=20'

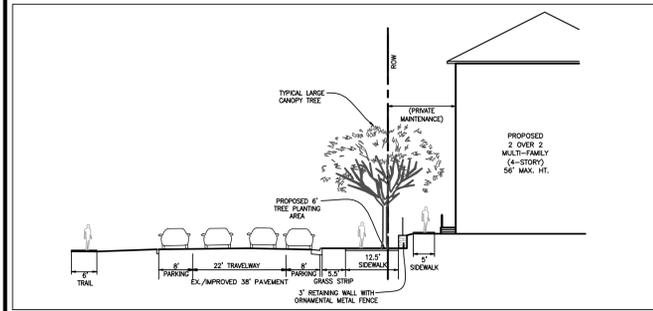


CROSS SECTION E-E

SCALE: 1"=20'

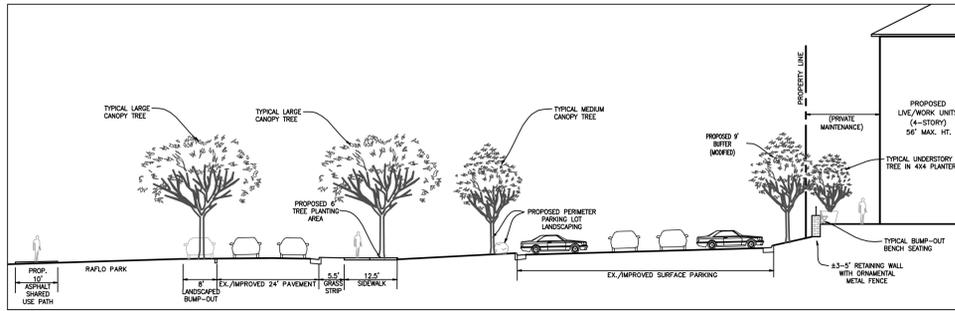


CROSS SECTION F-F

SCALE: 1"=20'

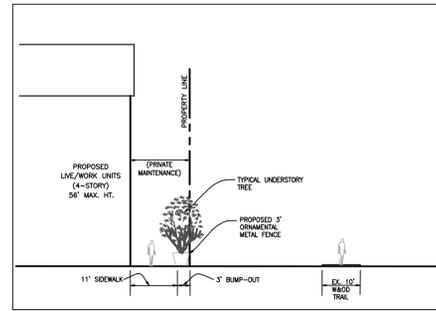


CROSS SECTION G-G

SCALE: 1"=20'

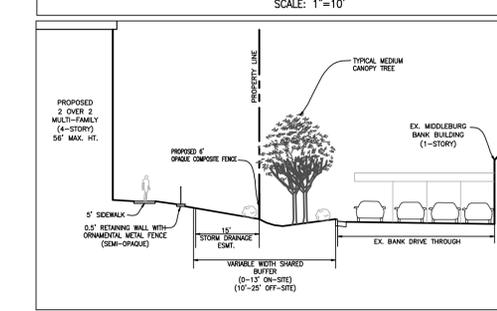


CROSS SECTION H-H

SCALE: 1"=20'

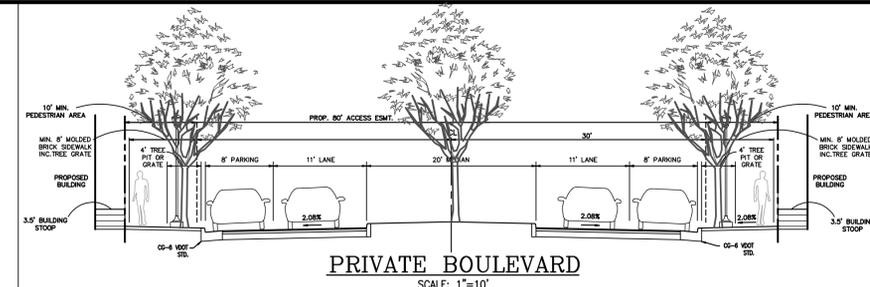


PRIVATE BOULEVARD

SCALE: 1"=10'

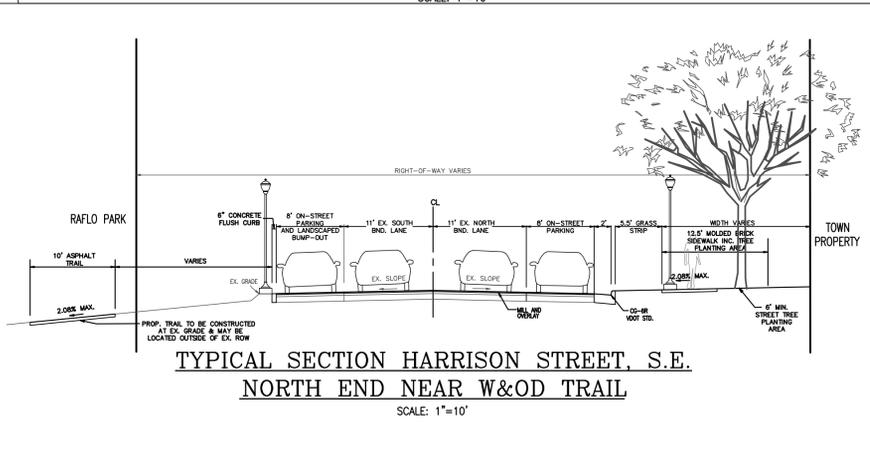


**TYPICAL SECTION HARRISON STREET, S.E.
NORTH END NEAR W&O TRAIL**

SCALE: 1"=10'

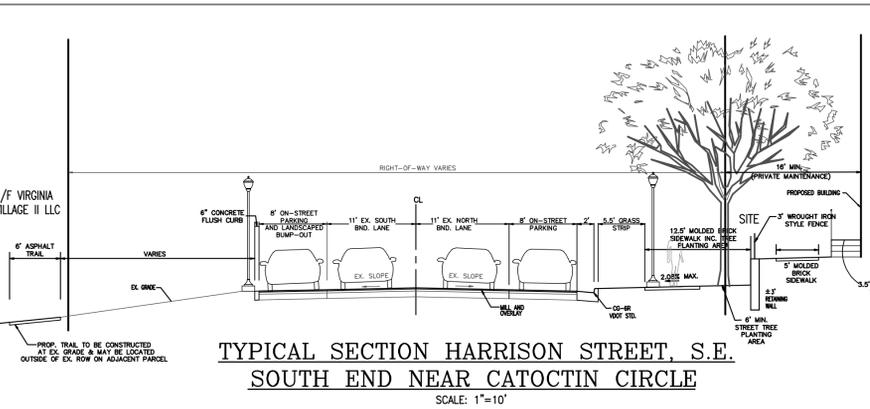


**TYPICAL SECTION HARRISON STREET, S.E.
SOUTH END NEAR CATOCTIN CIRCLE**

SCALE: 1"=10'

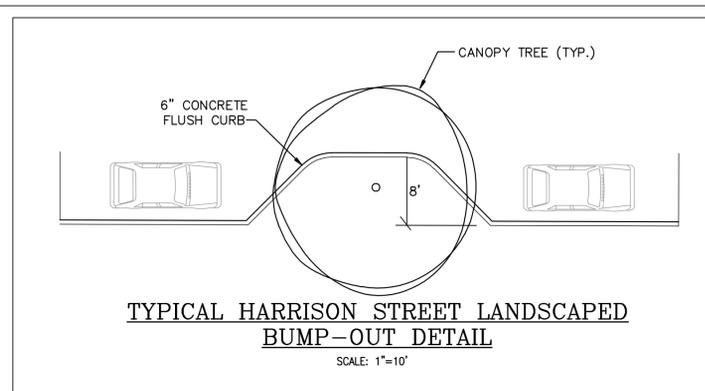


**TYPICAL HARRISON STREET LANDSCAPED
BUMP-OUT DETAIL**

SCALE: 1"=10'

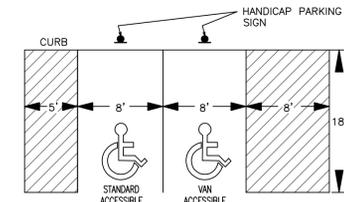

**ACCESSIBLE PARKING
BAY DETAIL**

NOT TO SCALE

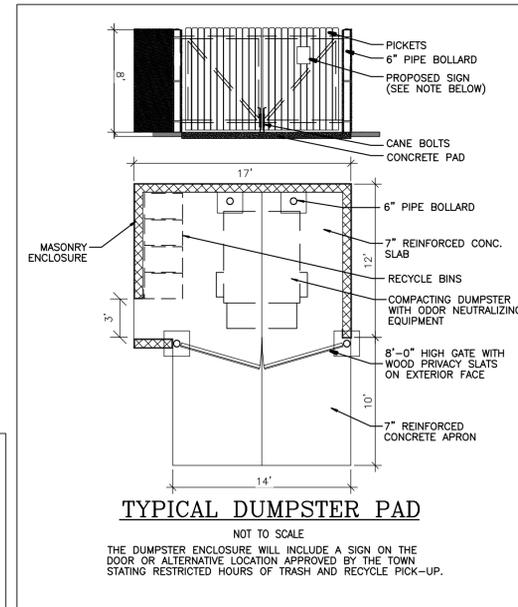


TYPICAL DUMPSTER PAD

NOT TO SCALE

THE DUMPSTER ENCLOSURE WILL INCLUDE A SIGN ON THE DOOR OR ALTERNATIVE LOCATION APPROVED BY THE TOWN STATING RESTRICTED HOURS OF TRASH AND RECYCLE PICK-UP.

TYPICAL SECTION NOTES:


1. SIDEWALKS WILL BE DESIGNED IN CONFORMANCE WITH DCSD DETAILS TS-12A AND TS-12B.

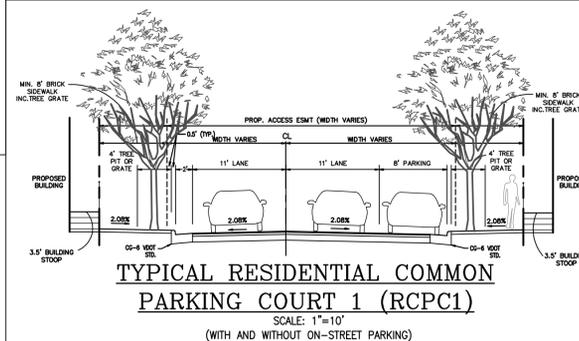

**TYPICAL RESIDENTIAL COMMON
PARKING COURT 1 (RCPC1)**

SCALE: 1"=10'

(WITH AND WITHOUT ON-STREET PARKING)

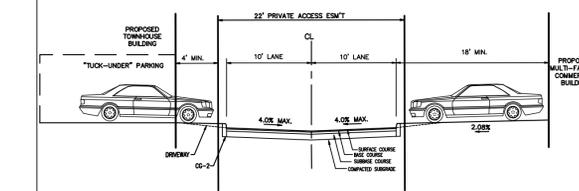

**TYPICAL RESIDENTIAL COMMON
PARKING COURT 2 (RCPC2)**

SCALE: 1"=10'

Bowman CONSULTING

Bowman Consulting Group, Ltd.
101 South Street, S.E.
Leesburg, Virginia 20175
Phone: (703) 443-2400
Fax: (703) 443-2425
www.bowmanconsulting.com

TOWN OF LEEBSBURG
LOUDOUN COUNTY, VIRGINIA
TLZM-2012-0003


TYPICAL SECTIONS AND DETAILS
CRESCENT PLACE
ZONING CONCEPT PLAN & PROFFER AMENDMENT

DATE	DESCRIPTION
11/20/12	PER CHECKLIST COMMENTS
3/28/13	PER 1ST SUB. COMMENTS
6/14/13	PER 2ND SUB. COMMENTS
8/14/13	PER PC COMMENTS
9/18/13	PER PC COMMENTS
10/07/13	PER PC COMMENTS
10/18/13	PER PC COMMENTS
11/01/13	PER TC COMMENTS


DATE	DESCRIPTION	
BBR DESIGN	JAE DRAWN	CHM CHKD
SCALE	H: AS SHOWN	V: Y
JOB No.	5371-01-003	
DATE	NOVEMBER 5, 2012	
FILE No.	5371-D-ZP-001	

SHEET 5 OF 24


Doc file name: \\c:\pds\new_projects\5371 - Crescent Place - Sub-Section & Reas\5371-01-003 (P.M) - Catoctin Circle Industrial Subdivision, ZOPA Typical Sections and Details.dwg

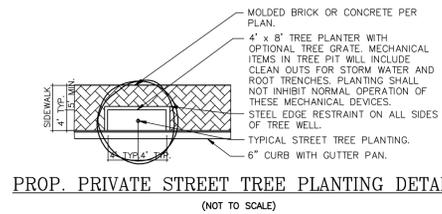


NOTE:
CONSTRUCTION METHODS TO ENSURE VABLE SOIL CONDITIONS FOR PRIVATE STREET TREES WILL BE SPECIFIED WITH FINAL ENGINEERING DESIGN.

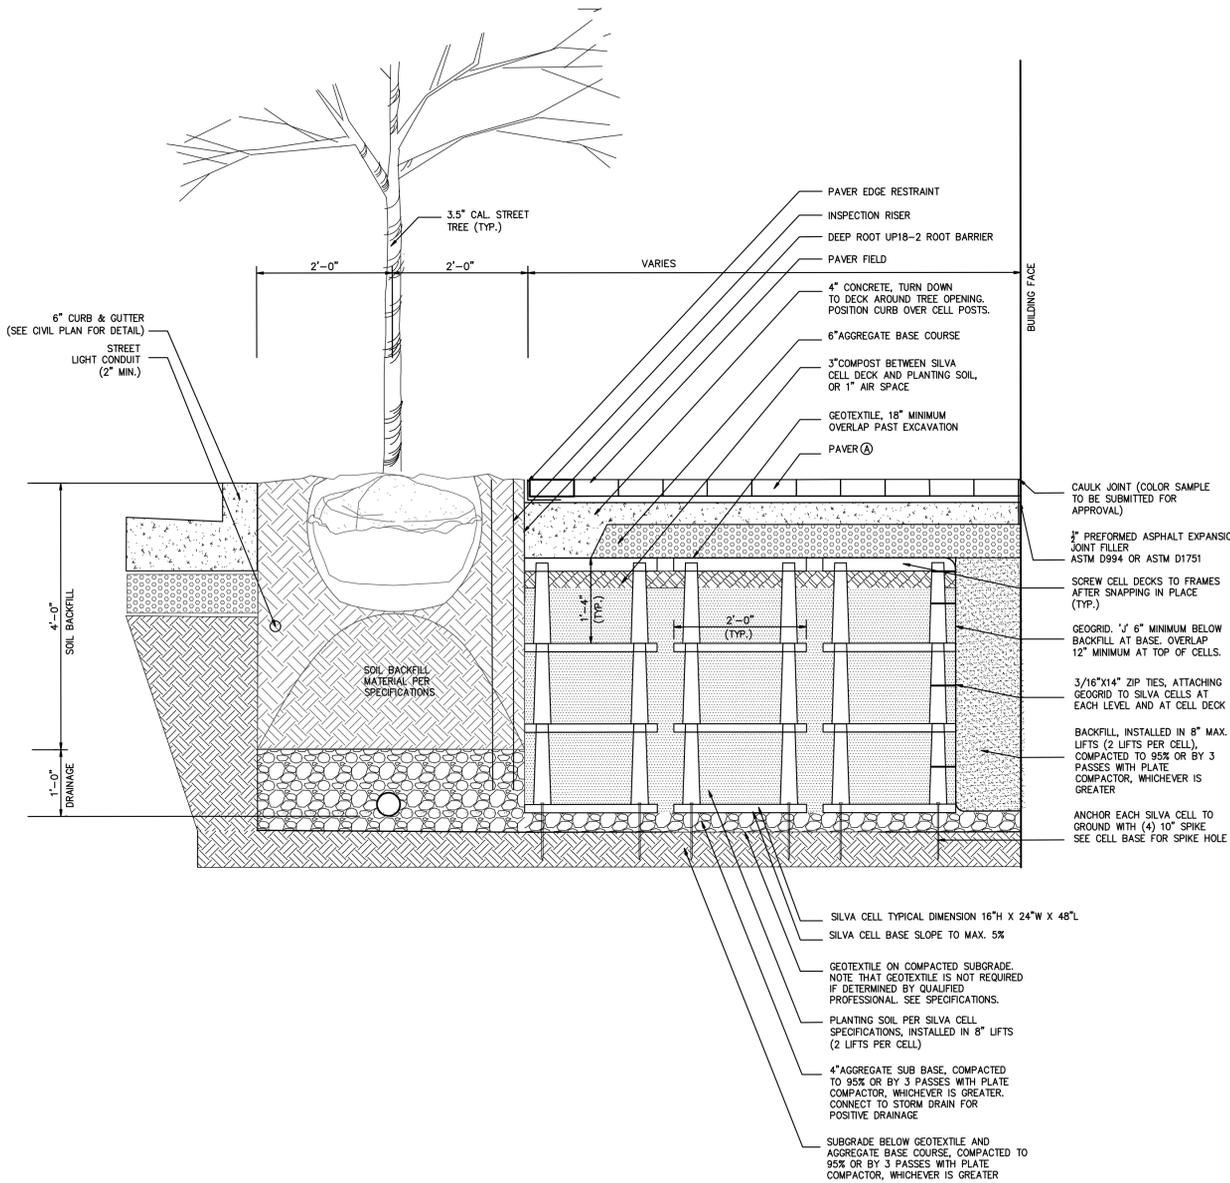


**TYPICAL SILVA CELL DETAIL
(PUBLIC STREET TREE PLANTING)**
(NOT TO SCALE)

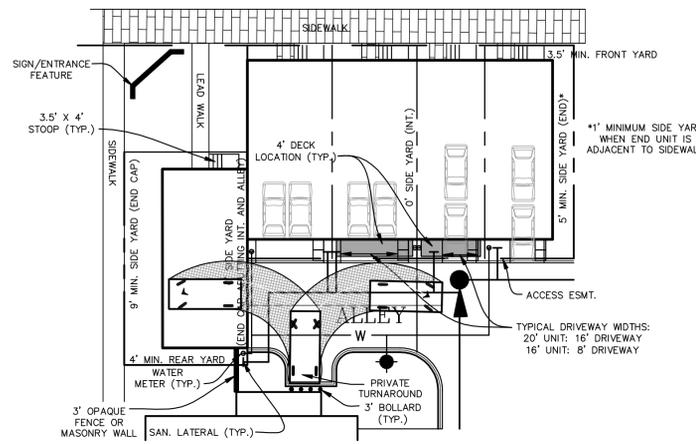


**TYPICAL TOWNHOUSE
(END CAP) LOT**
SCALE: 1"=20'

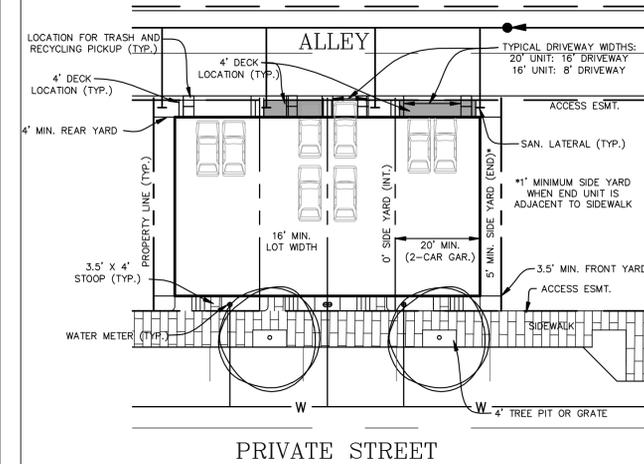


TYPICAL TOWNHOUSE LOT (REAR-LOAD)
SCALE: 1"=20'

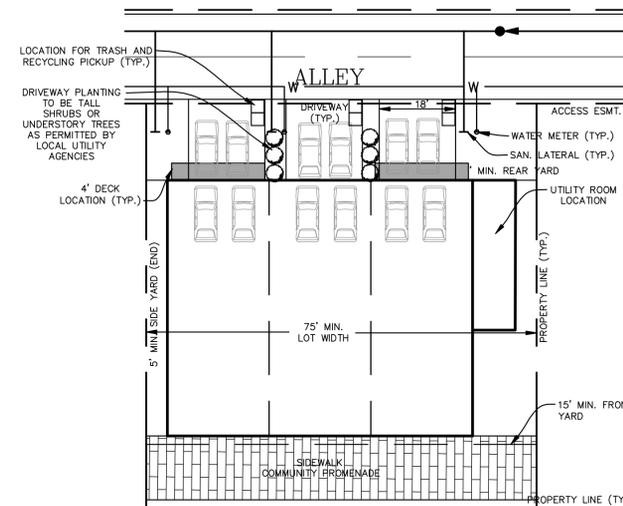

**TYPICAL MULTI-FAMILY
(LIVE/WORK) LOT**
SCALE: 1"=20'

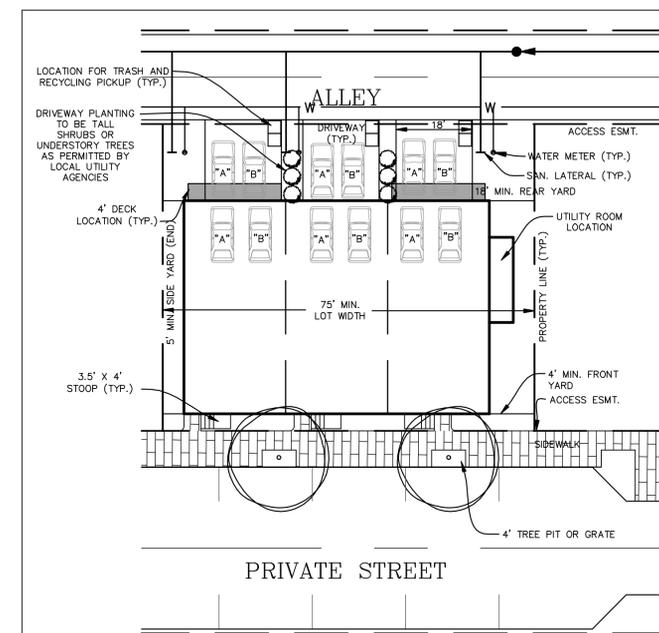

**TYPICAL MULTI-FAMILY
(2 OVER 2) LOT**
SCALE: 1"=20'

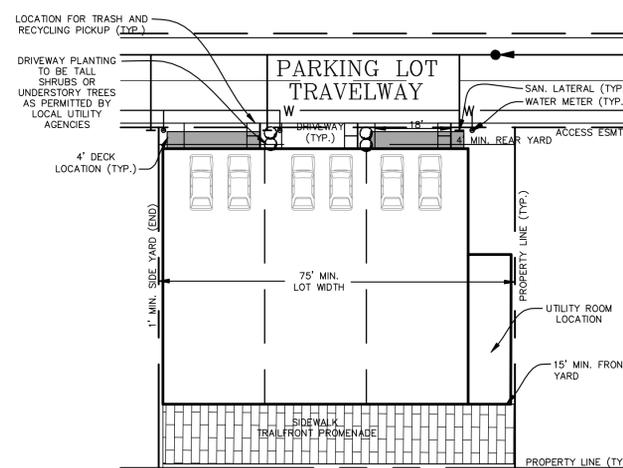

**TYPICAL BUILDING "C"
MULTI-FAMILY (LIVE/WORK) LOT**
SCALE: 1"=20'

TYPICAL UNIT NOTES:


- TRASH AND RECYCLING RECEPTACLES SHALL BE STORED WITHIN THE GARAGE.
- GARAGES SHALL BE MAINTAINED TO PROVIDE THE PARKING OF VEHICLES AT ALL TIMES AND SHALL BE ENFORCED VIA PROFFERED HOA RESTRICTIONS.
- SIDEWALKS WILL BE DESIGNED IN CONFORMANCE WITH DCSD DETAILS TS-12A AND TS-12B.

DATE	DESCRIPTION
11/20/12	PER CHECKLIST COMMENTS
3/28/13	PER 1ST SUB. COMMENTS
6/14/13	PER 2ND SUB. COMMENTS
8/14/13	PER PC COMMENTS
9/18/13	PER PC COMMENTS
10/07/13	PER PC COMMENTS
10/18/13	PER PC COMMENTS
11/01/13	PER TC COMMENTS

DATE	DESCRIPTION
BBR DESIGN	JAE DRAWN
	CMH CHKD
SCALE	H: AS SHOWN
	V:
JOB No.	5371-01-003
DATE	NOVEMBER 5, 2012
FILE No.	5371-D-ZP-001

LEGEND

- 306 --- EXISTING ONE FOOT CONTOUR
- 305 --- EXISTING FIVE FOOT CONTOUR
- 306 --- PROPOSED ONE FOOT CONTOUR
- 305 --- PROPOSED FIVE FOOT CONTOUR
- PROPOSED STORM PIPE
- PROPOSED STORM INLET
- RELOCATED SANITARY SEWER
- BOUNDARY
- PROPOSED BUILDING
- OVERLAND RELIEF

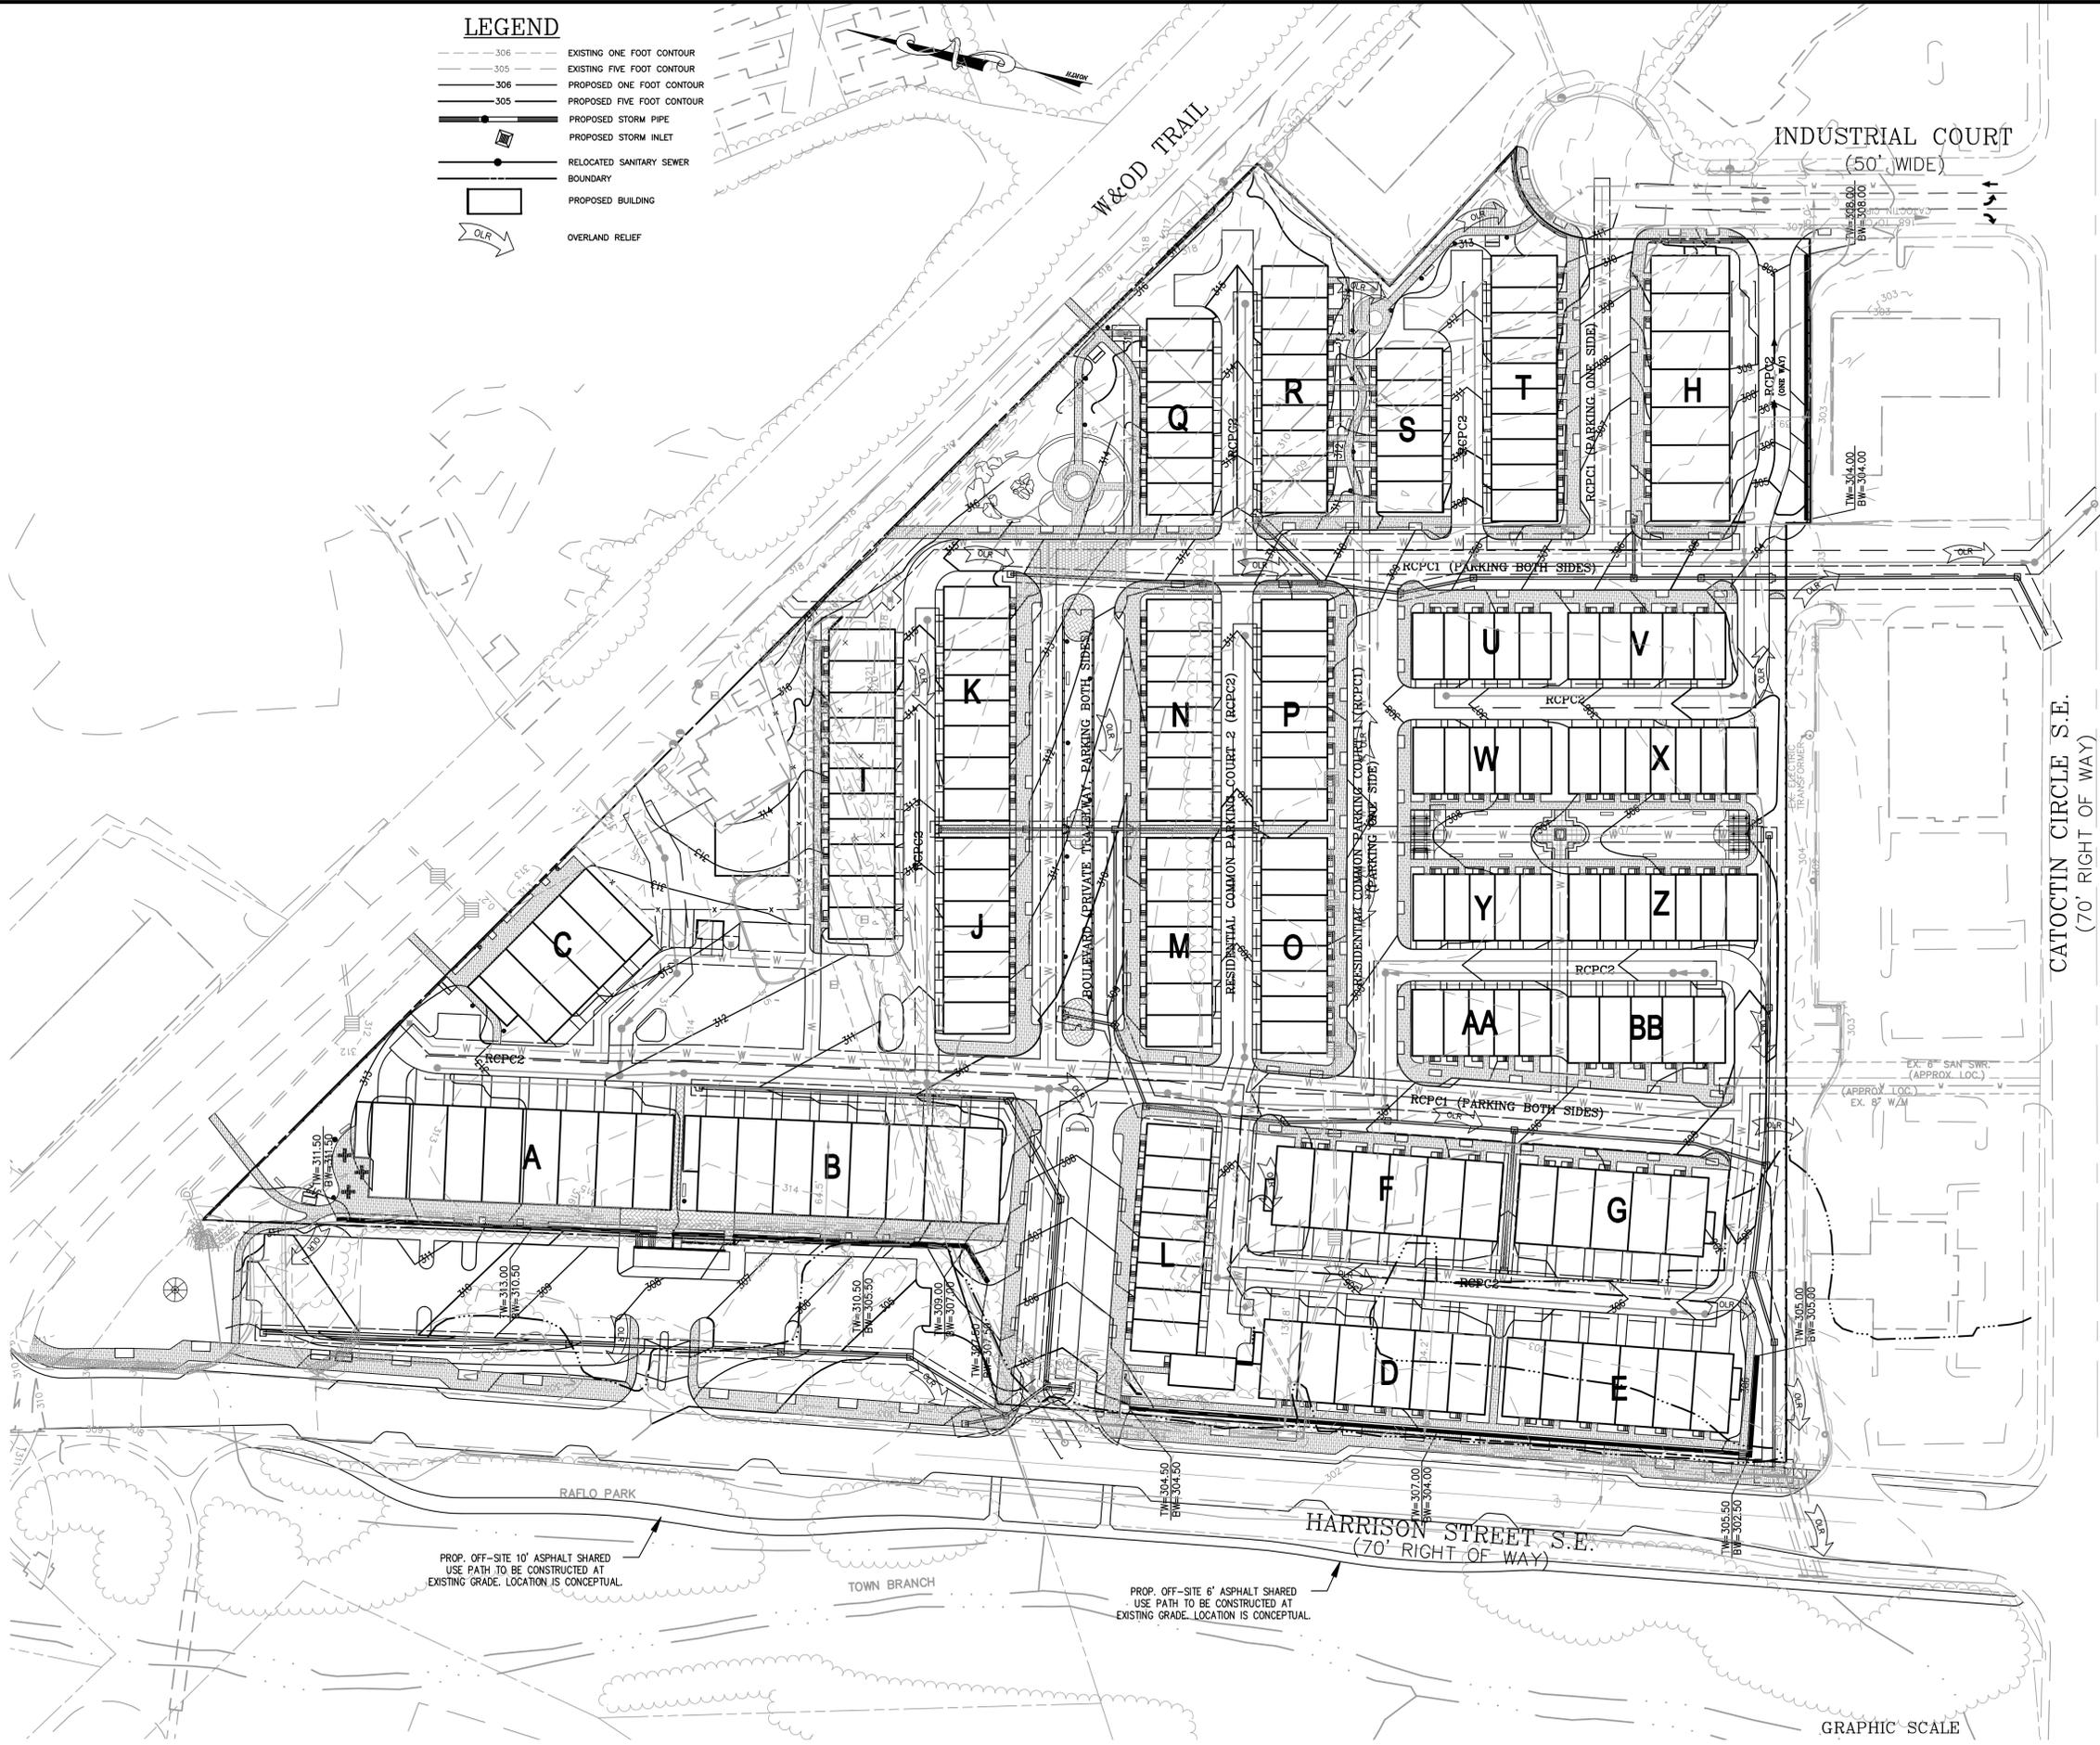


Bowman Consulting Group, Ltd.
101 South Street, S. E.
Leesburg, Virginia 20175
Phone: (703) 443-2400
Fax: (703) 443-2405
www.bowmanconsulting.com


GRADING PLAN
CRESCENT PLACE
ZONING CONCEPT PLAN & PROFFER AMENDMENT
TLZM-2012-0003 LOUDOUN COUNTY, VIRGINIA



DATE	DESCRIPTION	CMM
11/20/12	PER CHECKLIST COMMENTS	
3/28/13	PER 1ST SUB. COMMENTS	
6/14/13	PER 2ND SUB. COMMENTS	
8/14/13	PER PC COMMENTS	
9/18/13	PER PC COMMENTS	
10/07/13	PER PC COMMENTS	
10/18/13	PER PC COMMENTS	
11/01/13	PER TC COMMENTS	

DATE	DESCRIPTION	CMM
BBR	JAE	CMM
DESIGN	DRAWN	CHKD
SCALE	H: 1"=50'	V:
JOB No.	5371-01-003	
DATE	NOVEMBER 5, 2012	
FILE No.	5371-D-ZP-001	

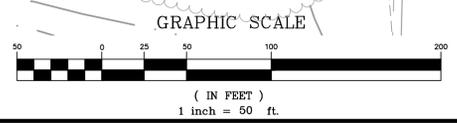

Doc file name: \\c:\pds\new_projects\5371 - Catocin Circle Ind. Sub-Station, 2DPA\Concept Grading Plan.rvt

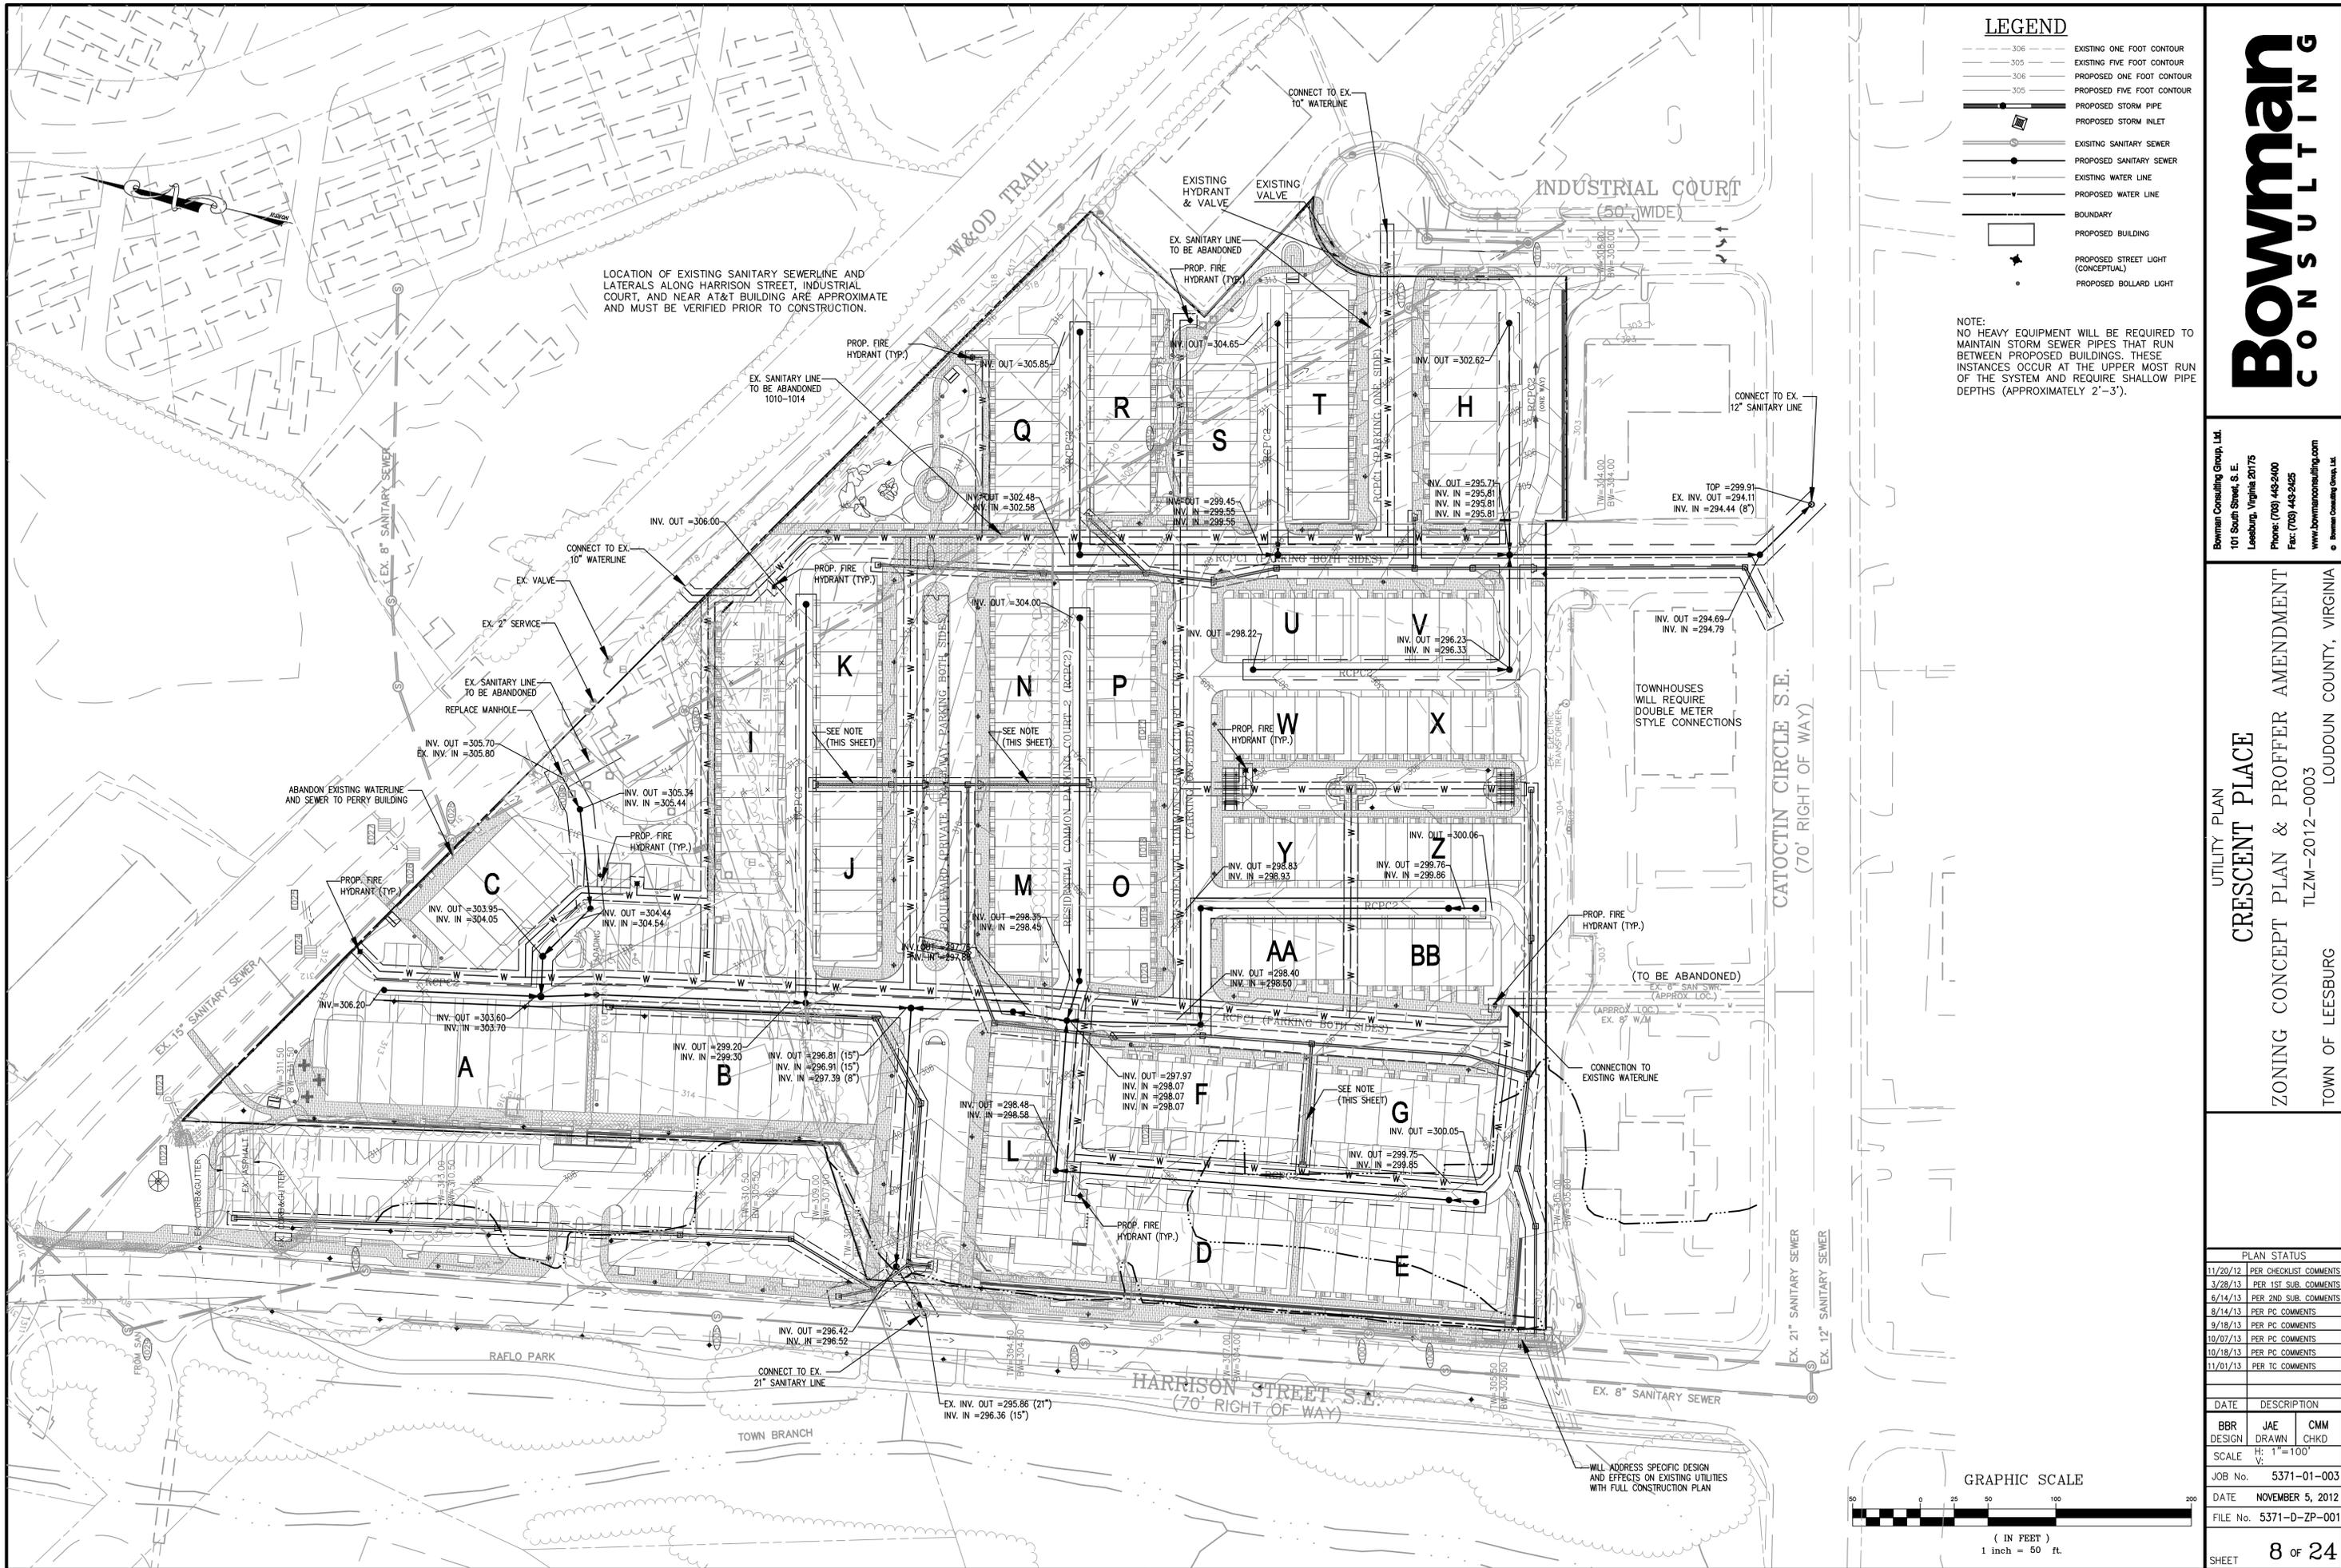

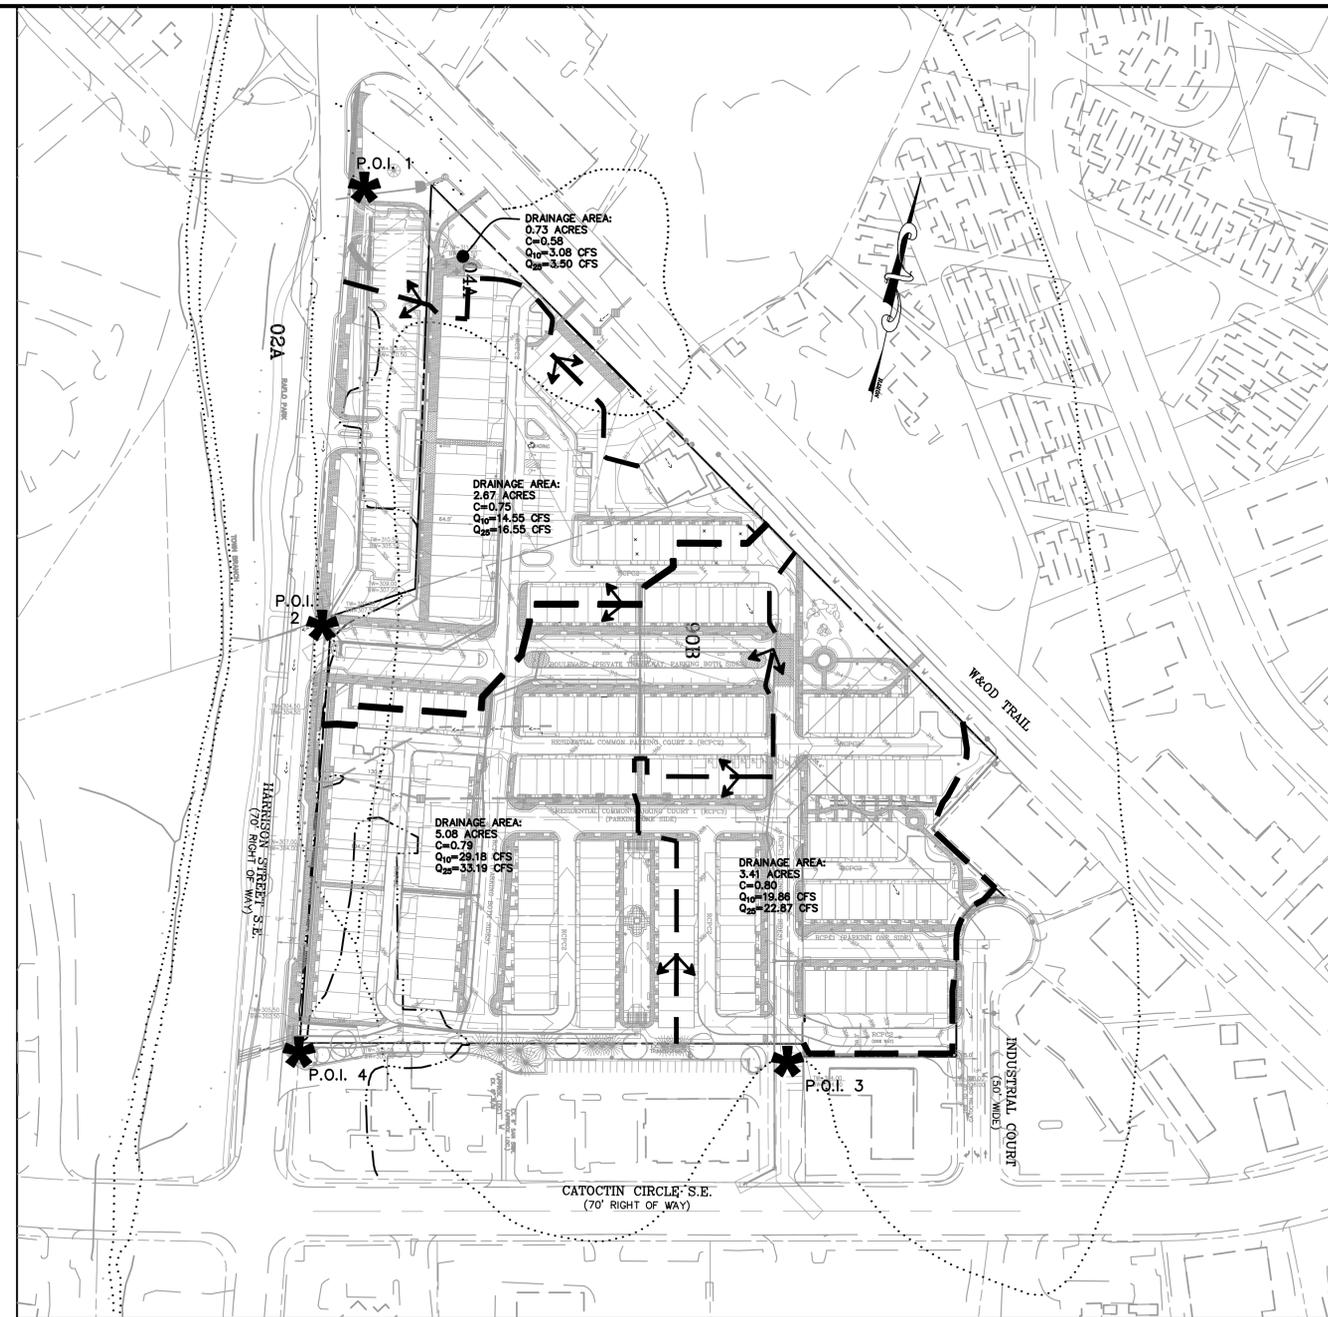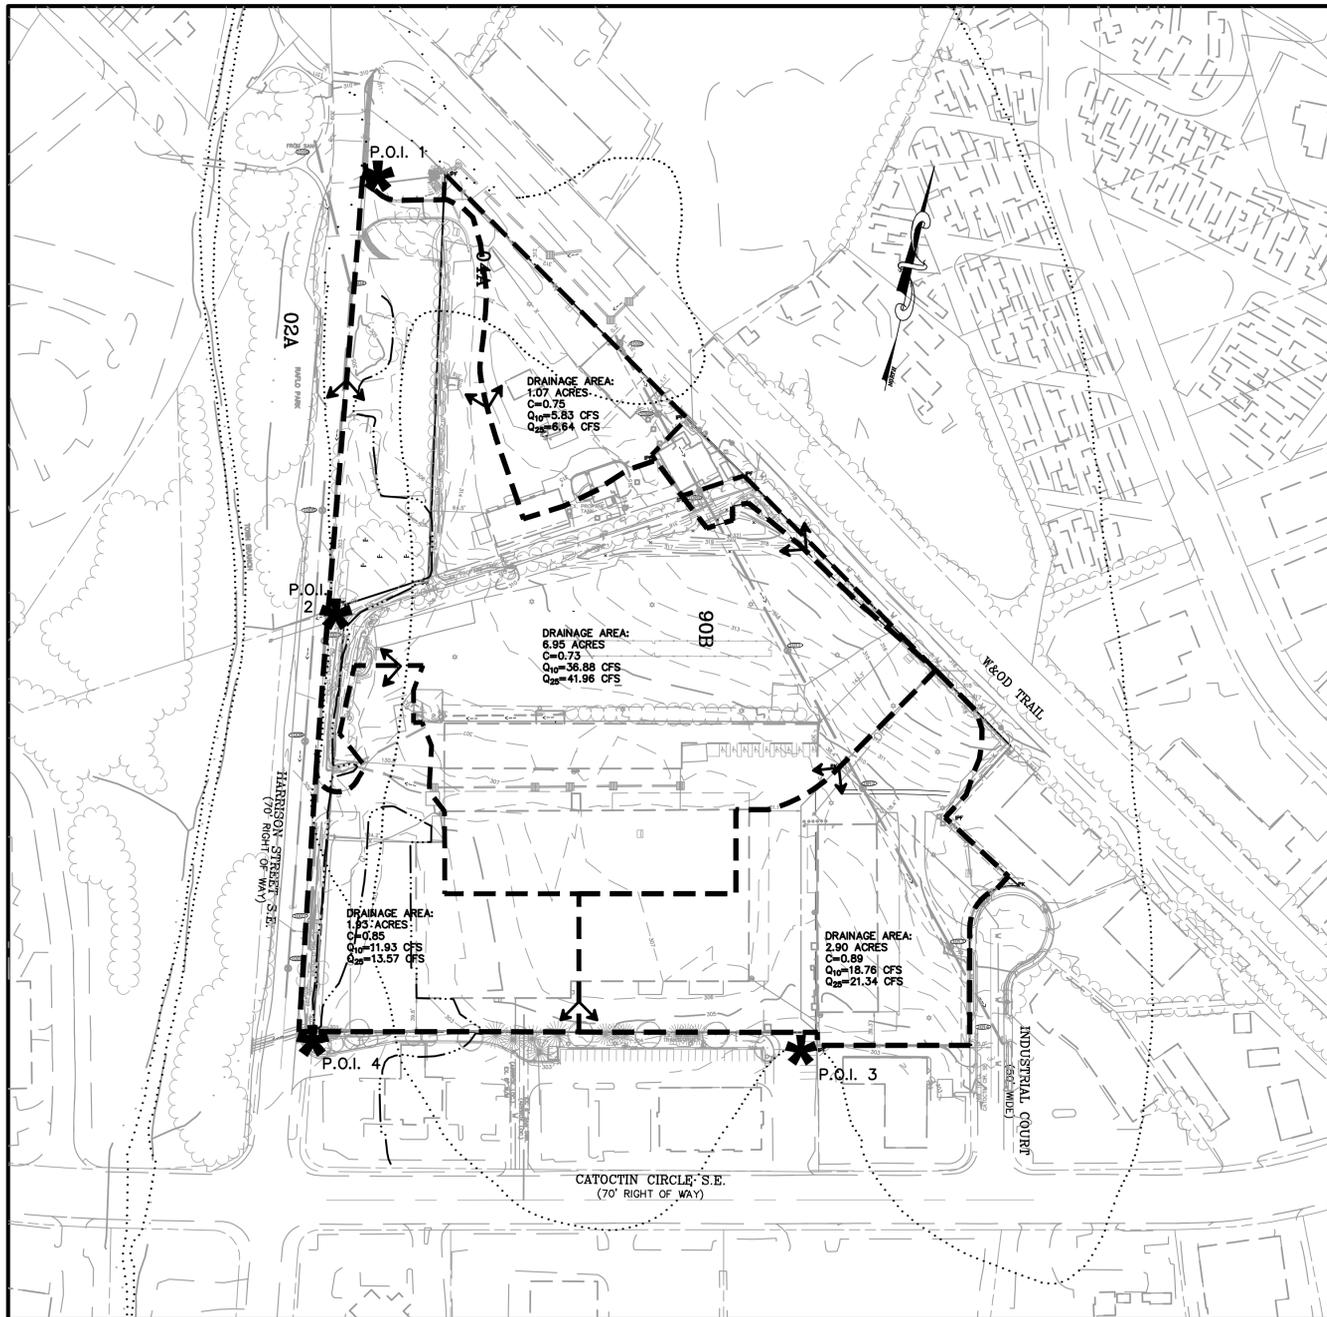

PRE-DEVELOPED DRAINAGE MAP

 
SCALE: 1"=100'

POST-DEVELOPED DRAINAGE MAP

SCALE: 1"=100'

ADEQUATE OUTFALL NARRATIVE


PRELIMINARY STORM WATER MANAGEMENT ANALYSIS REVEALS THAT DEVELOPMENT OF THE SITE WILL RESULT IN REDUCED PEAK RUN-OFF AT POINTS OF INTEREST (P.O.I.) #1 AND #2. P.O.I. #3 AND #4 WILL EXPERIENCE AN INCREASE IN PEAK RUN-OFF AND THE ADEQUACY OF THE DUAL CULVERTS UNDER HARRISON STREET AND THE EXISTING STORM SYSTEM ALONG CATOCTIN CIRCLE WILL BE VERIFIED UPON FINAL DESIGN.



DATE	DESCRIPTION
11/20/12	PER CHECKLIST COMMENTS
3/28/13	PER 1ST SUB. COMMENTS
6/14/13	PER 2ND SUB. COMMENTS
8/14/13	PER PC COMMENTS
9/18/13	PER PC COMMENTS
10/07/13	PER PC COMMENTS
10/18/13	PER PC COMMENTS
11/01/13	PER TC COMMENTS

DATE	DESCRIPTION	BY	CHKD
DESIGN	DRAWN	JAE	CMM
SCALE	H: AS SHOWN	V:	
JOB No.	5371-01-003		
DATE	NOVEMBER 5, 2012		
FILE No.	5371-D-ZP-001		
SHEET	9 OF 24		

Doc file name: \\c:\pds\new_projects\5371 - Catoctin Circle Ind. Sub-Station, 2D\PRELIMINARY SWM PLAN.dwg

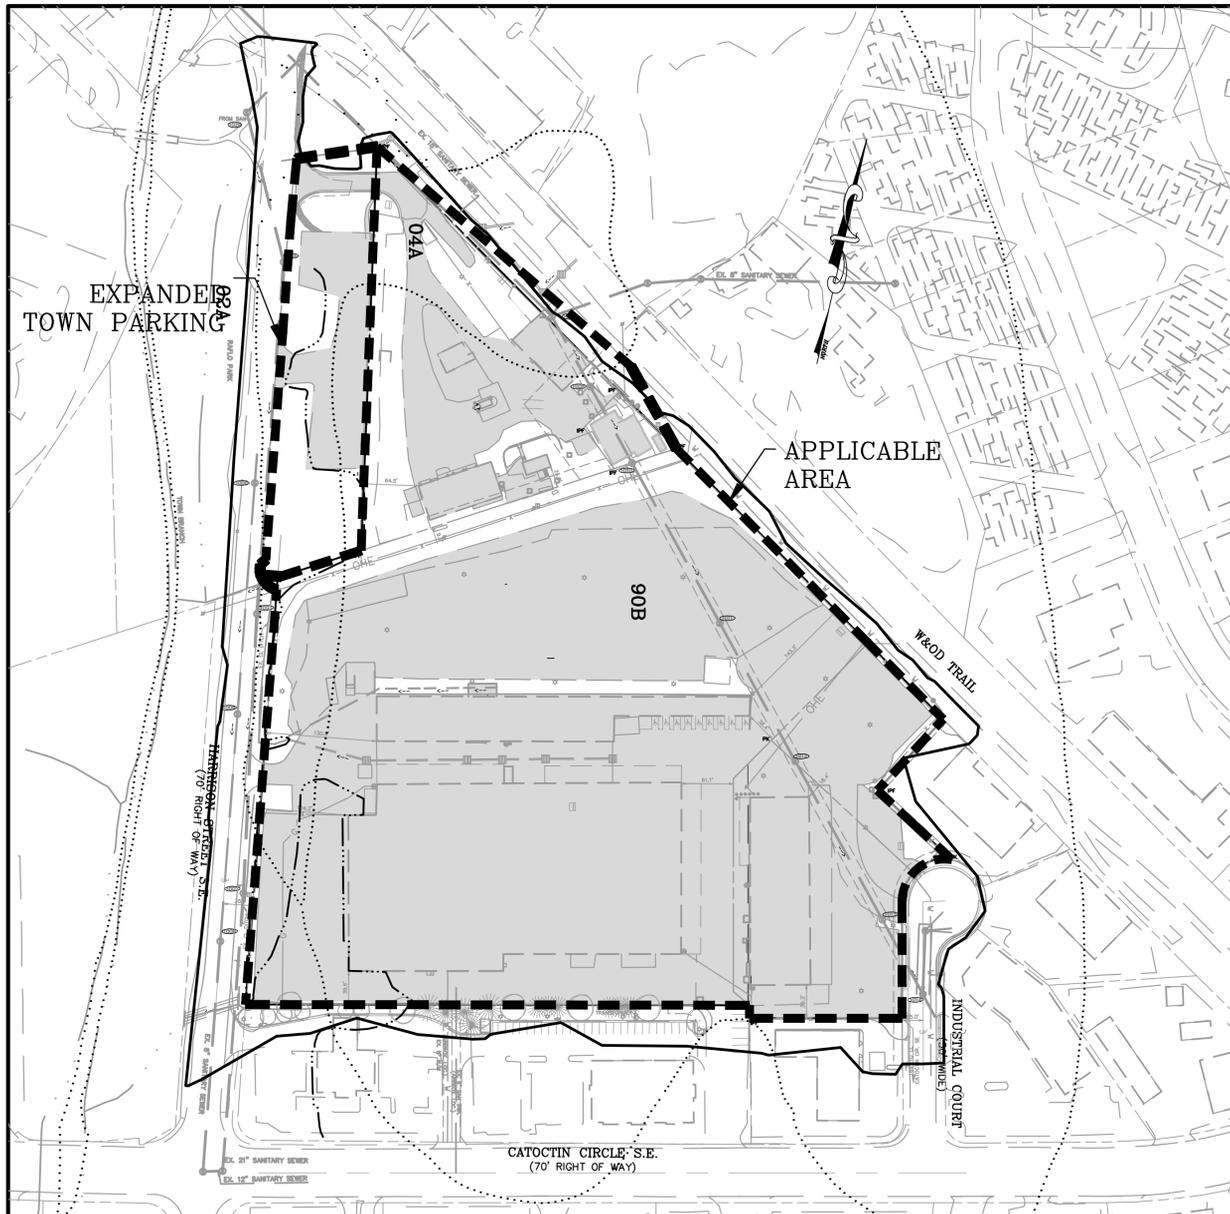

PRE-DEVELOPED IMPERVIOUS AREA MAP

SCALE: 1"=100'



POST-DEVELOPED IMPERVIOUS AREA MAP

SCALE: 1"=100'

LEGEND

IMPERVIOUS AREA

BMP NARRATIVE

BASED ON PRELIMINARY BMP CALCULATIONS SHOWN TO THE RIGHT, THE PROPOSED DEVELOPMENT WILL REDUCE IMPERVIOUS AREA BY 5%. BMPs WILL BE PROVIDED TO ACHIEVE AN ADDITIONAL 15% REDUCTION IN PHOSPHORUS LOADING. TYPE AND LOCATION TO BE DETERMINED AT FINAL DESIGN.

AT THE TIME OF CONSTRUCTION SITE PLAN SUBMISSION AND AS PART OF THE APPROVAL REQUIREMENT FOR CRESCENT PLACE ZONING APPLICATION, ALL FINAL BMP COMPUTATIONS AND STRATEGY SHALL COMPLY WITH THE LATEST REQUIREMENT OF THE NEW VIRGINIA STORMWATER MANAGEMENT REGULATIONS AND METHODOLOGY. REFER TO DCSM ART 5-610; DCSM ART 5-620; 4VAC 50-60-48; 4VAC 50-60-63; 4VAC 50-60-72.

Virginia Runoff Reduction Method Worksheet -- Revised -- 03/25/2011 - Redevelopment Site Data

Project Name: 5371-01-003 Crescent Place
Date: 06/04/2013

data input cells
calculation cells
constant values

Post-Development Project & Land Cover Information

Constants

Annual Rainfall (inches)	42
Target Rainfall Event (inches)	1.00
Phosphorus EMC (mg/L)	0.26
Target Phosphorus Target Load (lb/acre/yr)	0.41
Pj	0.90

Pre-Development Land Cover (acres)

	A soils	B Soils	C Soils	D Soils	Totals
Forest/Open Space (acres) -- undisturbed, protected forest/open space or reforested land	0.00	0.00	0.00	0.00	0.00
Managed Turf (acres) -- disturbed, graded for yards or other turf to be mowed/managed	0.00	0.00	0.00	2.71	2.71
Impervious Cover (acres)	0.00	0.00	0.00	10.22	10.22
Total					12.93

Post-Development Land Cover (acres)

	A soils	B Soils	C Soils	D Soils	Totals
Forest/Open Space (acres) -- undisturbed, protected forest/open space or reforested land	0.00	0.00	0.00	0.00	0.00
Managed Turf (acres) -- disturbed, graded for yards or other turf to be mowed/managed	0.00	0.00	0.00	3.28	3.28
Impervious Cover (acres)	0.00	0.00	0.00	9.65	9.65
Total					12.93

Rv Coefficients

	A soils	B Soils	C Soils	D Soils
Forest/Open Space	0.02	0.03	0.04	0.05
Managed Turf	0.15	0.20	0.22	0.25
Impervious Cover	0.95	0.95	0.95	0.95

Land Cover Summary

Pre-Development

Forest/Open Space Cover (acres)	0.00
Weighted Rv(forest)	0.00
% Forest	0%
Managed Turf Cover (acres)	2.71
Weighted Rv(turf)	0.25
% Managed Turf	21%
Impervious Cover (acres)	10.22
Rv(imperious)	0.95
% Impervious	79%
Total Site Area (acres)	12.93
Site Rv	0.80
Pre-Development Treatment Volume (acre-ft)	0.8655
Pre-Development Treatment Volume (cubic feet)	37,703
Pre-Development Load (TP) (lb/yr)	22.86

Land Cover Summary

Post-Development

Forest/Open Space Cover (acres)	0.00
Weighted Rv(forest)	0.00
% Forest	0%
Managed Turf Cover (acres)	3.28
Weighted Rv(turf)	0.25
% Managed Turf	25%
Impervious Cover (acres)	9.65
Rv(imperious)	0.95
% Impervious	75%
Total Site Area (acres)	12.93
Site Rv	0.77
Post-Development Treatment Volume (acre-ft)	0.8324
Post-Development Treatment Volume (cubic feet)	36,257
Post-Development Load (TP) (lb/yr)	21.99

 
Maximum % Reduction Required Below Pre-Development Load: 20%

Total Load (TP) Reduction Required (lb/yr): 3.70

Post-Development Load (TN) (lb/yr): 157.28

Pre-Development Load (TN) (lb/yr): 163.55


Nitrogen EMC (mg/L): 1.86



PLAN STATUS

11/20/12	PER CHECKLIST COMMENTS
3/28/13	PER 1ST SUB. COMMENTS
6/14/13	PER 2ND SUB. COMMENTS
9/14/13	PER PC COMMENTS
9/18/13	PER PC COMMENTS
10/07/13	PER PC COMMENTS
10/18/13	PER PC COMMENTS
11/01/13	PER TC COMMENTS

DATE	DESCRIPTION
BBR DESIGN	JAE DRAWN
	CMM CHKD
SCALE	H: AS SHOWN
	V: Y
JOB No.	5371-01-003
DATE	NOVEMBER 5, 2012
FILE No.	5371-D-ZP-001
SHEET	10 of 24

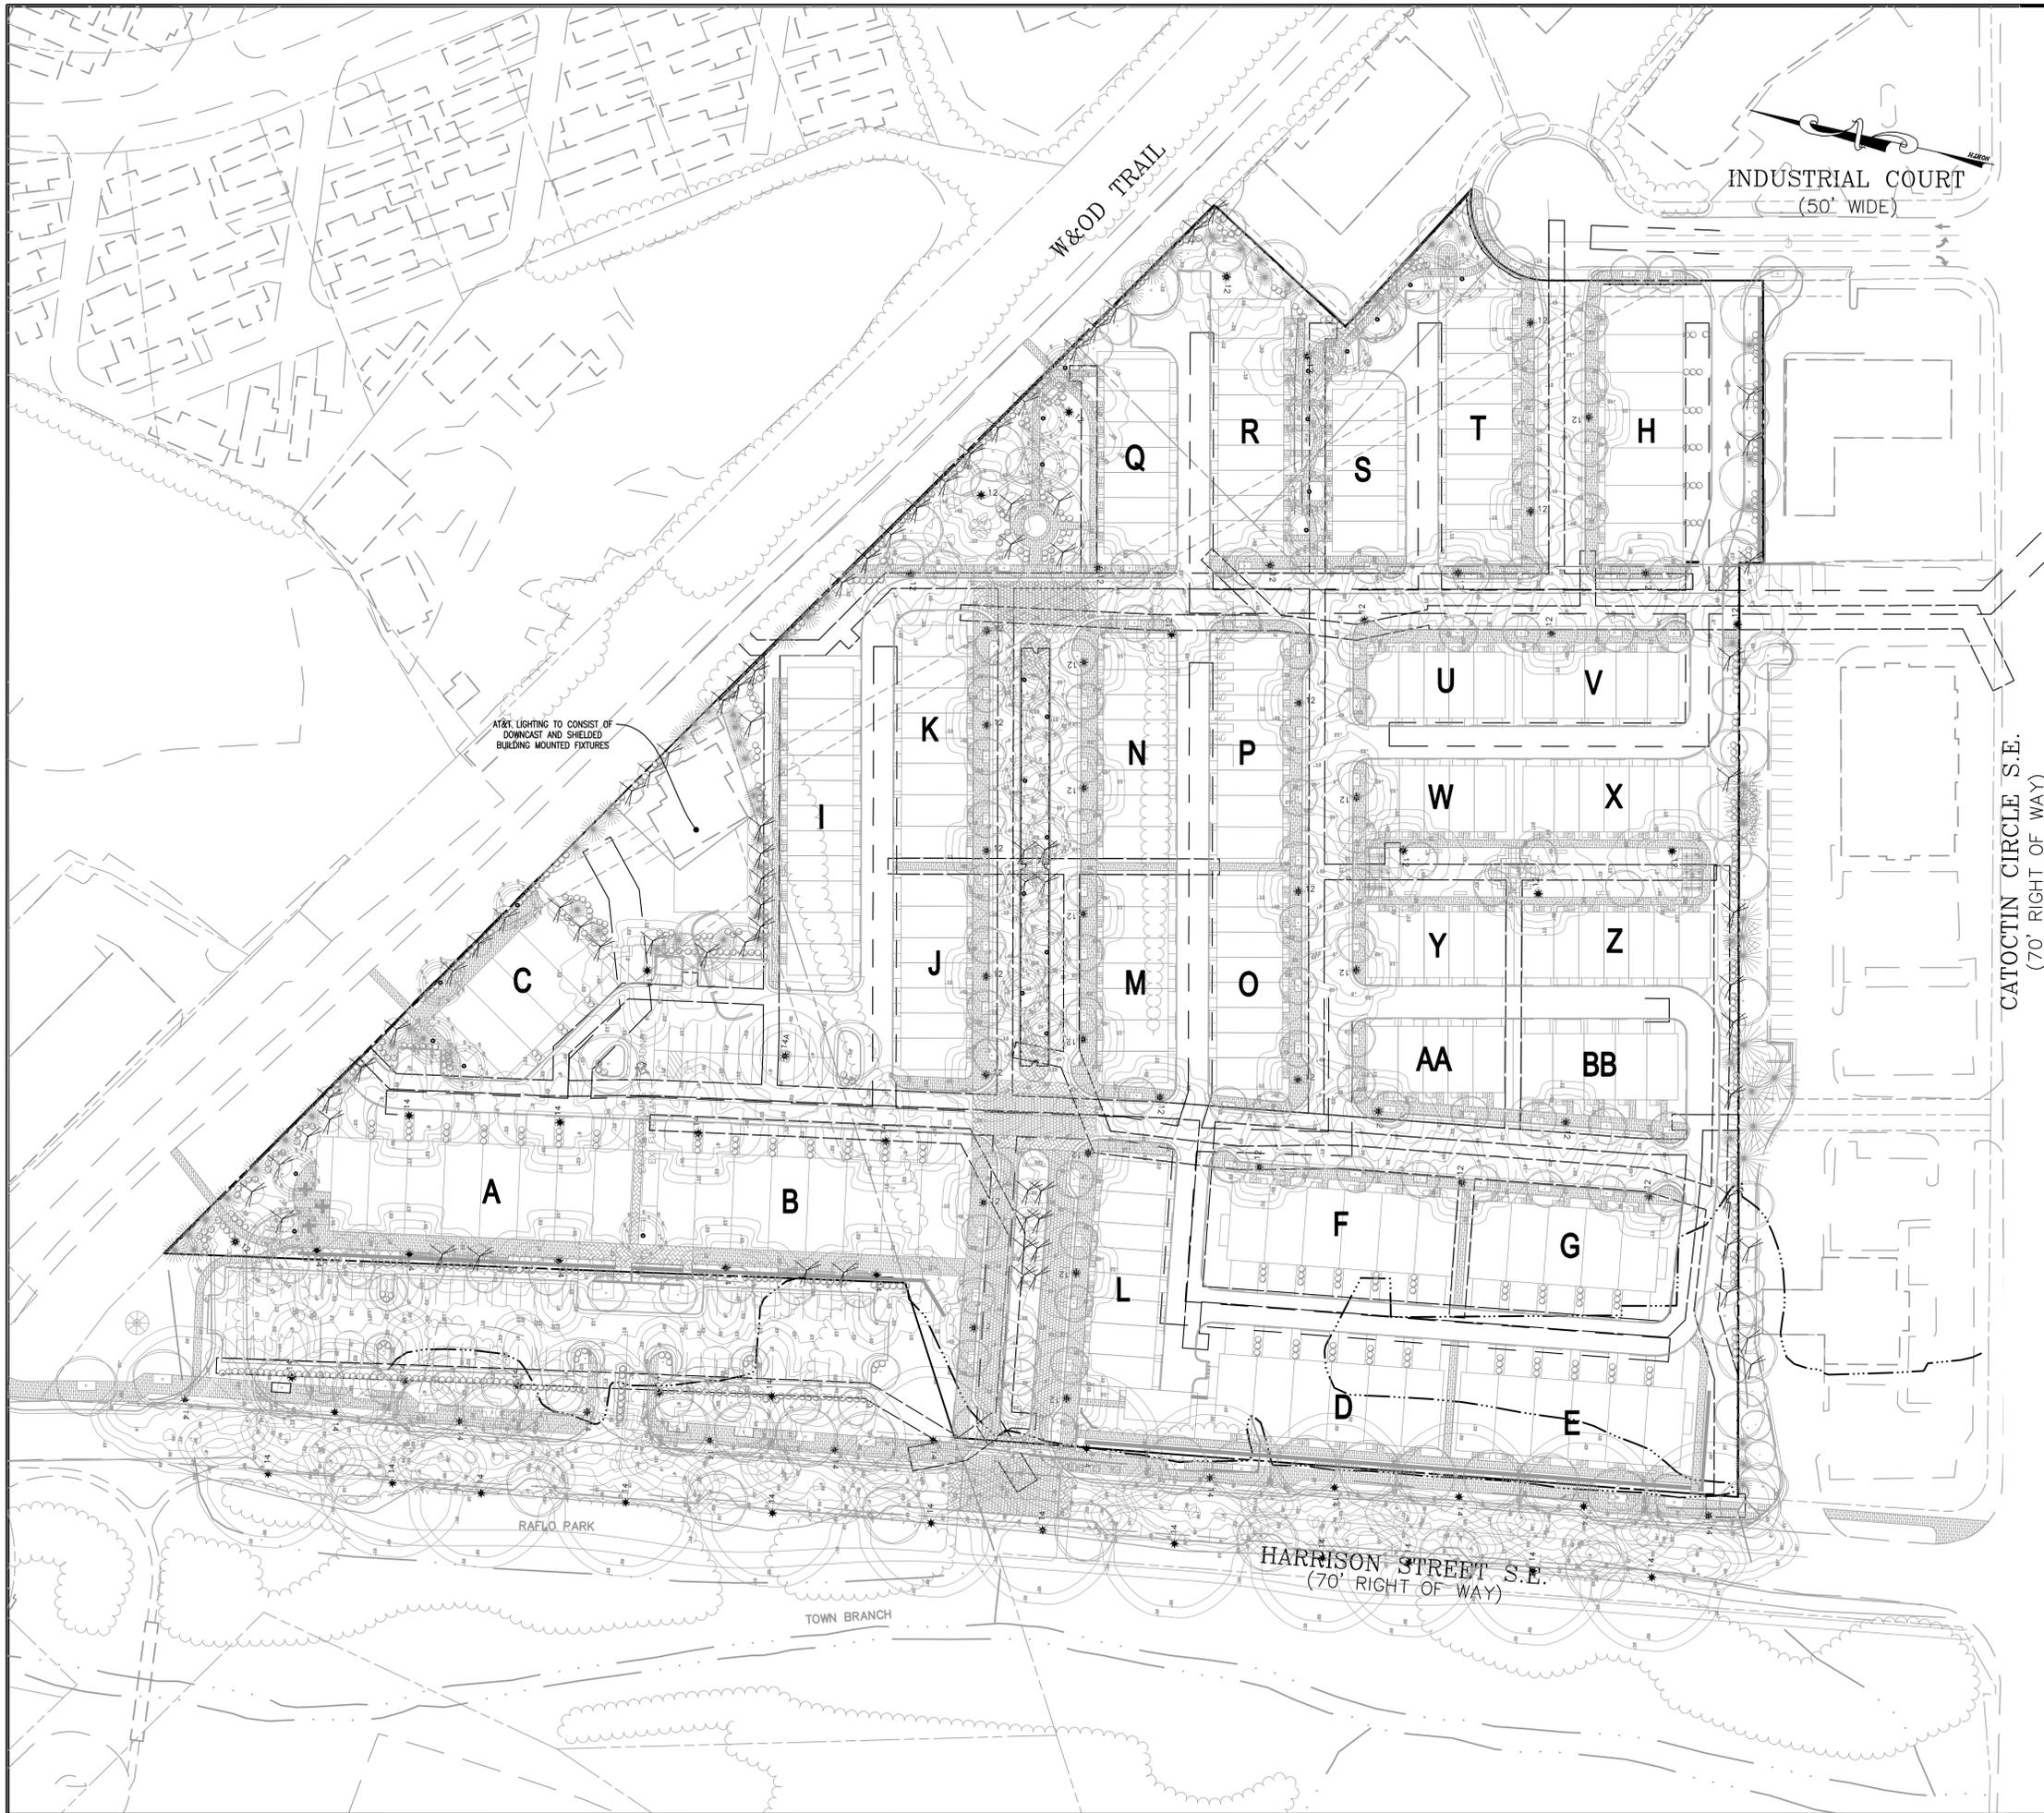

NOTES
 ALL SITE LIGHTING UNLESS OTHERWISE SPECIFIED HEREIN SHALL COMPLY WITH SEC. 12.11 OF THE ZONING ORDINANCE, WHICH STATES:
 ALL DEVELOPMENT SHALL COMPLY WITH THE OUTDOOR LIGHTING STANDARDS OF THE DESIGN AND CONSTRUCTION STANDARDS MANUAL, INCLUDING THE STANDARDS OF ARTICLE 7 AND THE FOLLOWING PROVISIONS:

1. A LIGHTING PLAN SHALL BE PROVIDED THAT INDICATES ALL OUTDOOR LIGHTING FIXTURES EXCLUSIVE OF STREET LIGHTS WILL NOT HAVE A SOURCE OF ILLUMINATION THAT IS VISIBLE BEYOND THE SITE OR CAUSE ILLUMINATION OF ADJACENT PROPERTIES IN EXCESS OF 0.5 FOOT-CANDLES, AS MEASURED AT THE SITE BOUNDARY.
2. ALL OUTDOOR LIGHTING FIXTURES SHALL BE DESIGNED, SHIELDED, AIMED, LOCATED AND MAINTAINED TO SHIELD ADJACENT PROPERTIES AND TO NOT PRODUCE GLARE ONTO ADJACENT PROPERTIES OR ROADWAYS. PARKING LOT LIGHT FIXTURES AND ALL LIGHT FIXTURES ON BUILDINGS SHALL BE FULL CUT-OFF FIXTURES WITH THE EXCEPTION THAT LANTERN-STYLE LIGHTS AND ACORN LIGHTS WHICH MAY BE MODIFIED CUT-OFF FIXTURES.


A TIMER OPERATED LIGHT FIXTURE SHALL BE PROVIDED ON THE REAR OF EACH DWELLING UNIT TO PROVIDE SECURITY LEVEL ILLUMINATION IN ALLEYS (RPC2). THE HOA SHALL HAVE THE AUTHORITY TO REPAIR AND/OR REPLACE SUCH FIXTURES.

AT&T LIGHTING TO CONSIST OF DOWNCAST AND SHIELDED BUILDING MOUNTED FIXTURES

LEGEND

- *14 PROPOSED STREET LIGHT-14' HT
- *14A PROPOSED STREET LIGHT-14' HT
- *12 PROPOSED STREET LIGHT-12' HT
- PROPOSED BOLLARD LIGHT-3' HT

APPROXIMATE LIGHT DISTRIBUTION

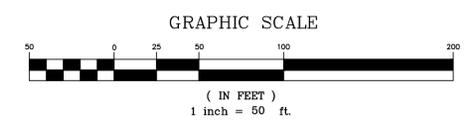


Bowman Consulting Group, Ltd.
 101 South Street, S. E.
 Leesburg, Virginia 20175
 Phone: (703) 443-2400
 Fax: (703) 443-2405
 www.bowmanconsulting.com
 © Bowman Consulting Group, Ltd.

LIGHTING PLAN
CRESCENT PLACE
 ZONING CONCEPT PLAN & PROFFER AMENDMENT
 TLZM-2012-0003
 TOWN OF LEEBSBURG
 LOUDOUN COUNTY, VIRGINIA

DATE	DESCRIPTION
11/20/12	PER CHECKLIST COMMENTS
3/28/13	PER 1ST SUB. COMMENTS
6/14/13	PER 2ND SUB. COMMENTS
8/14/13	PER PC COMMENTS
9/18/13	PER PC COMMENTS
10/07/13	PER PC COMMENTS
10/18/13	PER PC COMMENTS
11/01/13	PER TC COMMENTS

DATE	DESCRIPTION
BBR DESIGN	JAE DRAWN
	CMM CHKD
SCALE	H: N.T.S.
	V: 1/2"
JOB No.	5371-01-003
DATE	NOVEMBER 5, 2012
FILE No.	5371-D-ZP-001


Doc file name: \\c:\pds\new_projects\5371 - Catoctin Circle Ind. Sub-Station & Res\5371-01-003 (P11) - Catoctin Circle Industrial Substation, ZPA Lighting Plan.dwg

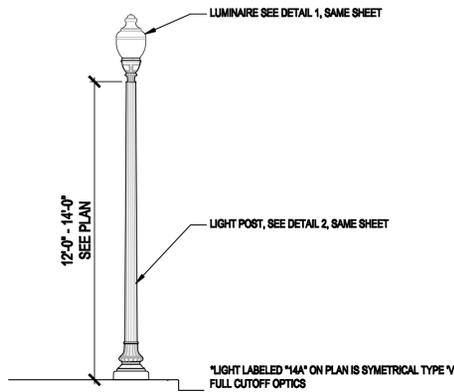

TYPICAL STREET LIGHT DETAIL
N.T.S.

NOTE:

- POLE HEIGHT INCLUDES BASE.
- LUMINAIRE PRODUCT SPECIFICATIONS TO BE PROVIDED WITH FINAL ENGINEERING AND INCORPORATED INTO CORRESPONDING PHOTOMETRIC ANALYSIS ACCORDINGLY.
- THE LIGHT BULB MUST BE COMPLETELY IN THE OPAQUE TOP (CROWN) OF THE FIXTURE AND NOT PROTRUDE BEYOND THE BOTTOM OF THE CROWN.
- THIS PLAN ONLY DEPICTS GENERAL LIGHT LOCATIONS AND LIGHTING DISTRIBUTION PATTERNS. FINAL LIGHT LOCATIONS AND LIGHTING DISTRIBUTION PATTERNS SHALL BE DETERMINED WITH PHOTOMETRIC ANALYSIS AT FINAL ENGINEERING.
- SHIELDS SHALL BE ADDED TO STREETLIGHTS TO MORE EFFECTIVELY DILUTE THE AMOUNT OF LIGHT THAT IS CAST UPON THE DWELLING UNITS.

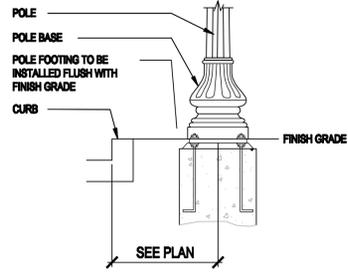

Decorative Acorn
The Decorative Acorn style luminaire complements urban streetscapes and pedestrian lighting applications with high color rendering and cutoff optics.

- Decorative cast aluminum base pod available with a matte black or dark green (fluted pole only) paint finish.
- Top mounted high performance Type III reflector with clear acrylic globe and black decorative chimney.
- Metal Halide lamping in 100 and 150 watts.
- Decorative composite poles standard.



Luminaires:

Lamp Type	Nominal Lamp Watts	Nominal/Mean Lamp Lumen	Finish Color	Initial Lamp Lumen	Input Voltage	Recommended Mounting Height	Percent Uplight	WMIS CU	Luminaire Stock #
MH	100	7,000	Matte Black	9000	124	*12 ft.	0.6 %	LDAC7MH	42062549
MH	150	10,000	Matte Black	13000	173	14 ft.	0.6 %	LDAC10MH	42062551
MH	100	7,000	Dark Green	9000	124	12 ft.	0.6 %	LDAC7MHGN	42062550
MH	150	10,000	Dark Green	13000	173	14 ft.	0.6 %	LDAC10MHGN	42062552

Poles Available:

- Decorative Round Tapered Composite - Standard
- Decorative Round Tapered Fluted Composite - Standard

*MOUNTING HEIGHT VARIES, SEE PLAN

1 STREET LIGHT
PRODUCT INFORMATION

N.T.S.



Pole - Decorative Round Tapered Fluted Composite


Fluted round tapered poles constructed of heavy duty fiberglass reinforced pigmented polyester plastic resin with a decorative base for pole top luminaires.



- Poles available directly embedded or base mounted for use with underground supply conductors only.
- Single pole top luminaire only.
- Available for use with:
Decorative Colonial Luminaire
Acorn Luminaire
Caryle Acorn Luminaire
Decorative Acorn Luminaire
- Anchor base poles require customer provided pole foundation and anchor bolts.

Pole Specifications:

Total Length (Feet)	Base Diameter (Inches)	Base Height (Inches)	Pole Top Diameter (Inches)	Embed Depth (Feet)	Luminaire Mounting Height (Feet)	Tension Size	Finish Color	WMIS CU Assembly	Pole Only Stock #
13	16.5	20.0	5.0	3.0	10.0	3.0" O.D. X 3.5"	Black (RAL 9005)	PPF13	50498500
15	16.5	20.0	5.0	3.0	12.0	3.0" O.D. X 3.5"	Black (RAL 9005)	PPF15	50499000
15	16.5	20.0	5.0	3.0	12.0	3.0" O.D. X 3.5"	Dark Green (RAL 9005)	PPF15GN	42062744
18	16.5	20.0	5.0	4.0	14.0	3.0" O.D. X 3.5"	Black (RAL 9005)	PPF18	50499200
18	16.5	20.0	5.0	4.0	14.0	3.0" O.D. X 3.5"	Dark Green (RAL 9005)	PPF18GN	42062745
10	16.5	20.0	5.4	A.B.	10.0	3.0" O.D. X 3.5"	Black (RAL 9005)	PPF10AB	50497900
12	16.5	20.0	5.4	A.B.	12.0	3.0" O.D. X 3.5"	Black (RAL 9005)	PPF12AB	50498100
12	16.5	20.0	5.4	A.B.	12.0	3.0" O.D. X 3.5"	Dark Green (RAL 9005)	PPF12ABGN	42062746
14	16.5	20.0	5.4	A.B.	14.0	3.0" O.D. X 3.5"	Black (RAL 9005)	PPF14AB	50498300
14	16.5	20.0	5.4	A.B.	14.0	3.0" O.D. X 3.5"	Dark Green (RAL 9005)	PPF14ABGN	42062757

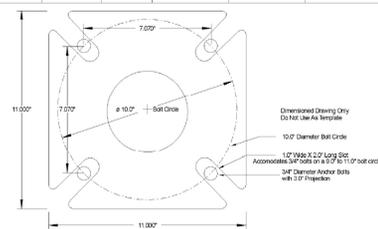

*MOUNTING HEIGHT VARIES, SEE PLAN

2 HARRISON STREET LIGHT
PRODUCT INFORMATION

N.T.S.

BOLLARD
BS700 Square and BR800 Round Bollards

Philips Gardco's family of 8" diameter round and 6.34" square bollards provides uniform illumination, superior spacings and remarkable brightness control. Rugged construction and cast construction with silicone seals and gasketing assure years of trouble free service. Each Gardco bollard utilizes 35w through 100w high intensity discharge lamps.

PREFIX	HEIGHT	WATTAGE	VOLTAGE	FINISH	OPTIONS
BR800	36	70MH	120	BLP	

PREFIX	HEIGHT	WATTAGE	FINISH	OPTIONS	
BS700	Square	42"	50MH	35HPS	INC 100w maximum A19
BR800	Round	36"	70MH	50HPS	
		30"	100MH	70HPS	
		24"		100HPS	

VOLTAGE	FINISH	OPTIONS
120	BRP Bronze Paint	OC Optional Color Paint
208	BLP Black Paint	SPC Specify RAL designation as per CCA41702-E
240	WFP White Paint	
277	NP Natural Aluminum Paint	SC Special Color Paint
	VP Verde Green Paint	Specify. Most supply color chip.

OPTIONS

- F Fixing
- SMD Internal 180° Shield
- DUP Duplex Receptacle weatheright, flush-mounted in lower housing
- GFCI GFCI Receptacle weatheright, flush-mounted in lower housing

1611 Clovis Barker Road, San Marcos, TX 78666
(800) 227-0758 (512) 753-1000 FAX: (512) 753-7855 sitelighting.com
© 2011 Koninkl Philips Electronics N.V. All Rights Reserved.
Philips Gardco reserves the right to change materials or modify the design of its product without notification as part of the company's continuing product improvement program.
79115-33-0511



BOLLARD
BS700 Square and BR800 Round Bollards

SPECIFICATIONS

GENERAL DESCRIPTION: Each Philips Gardco BS700 and BR800 is a bollard luminaire utilizing 35w through 100w high intensity discharge lamps. Luminaires feature a precision anodized aluminum reflector system which provides low glare uniform illumination and wide spacing. Units are totally sealed and gasketed preventing intrusion of moisture, dust and insects into the optical or electrical chambers.


HOUSING: Top and bottom housings are .125" (.318 cm) for the round or .156" (.396 cm) for the square high strength 6063-T5 extruded aluminum. Bottom section has a welded-in cast ring for attachment to base assembly with four (4) hex head set screws.

LENS: The lens is .250" (.634 cm) (round) or .312" (.792 cm) (square) clear virgin acrylic positioned between upper and lower housing sections. Silicone gasket completely seals unit and permits thermal expansion.


OPTICAL SYSTEM: Electrochemically anodized die formed aluminum reflector provides efficient illumination and brightness control. Hammer tone reflector assures clean, unstriated beam pattern.

SOCKET: Medium base pulse rated lampholder is glazed porcelain with nickel plated reinforced screw shell and spring loaded contact.

DIMENSIONS

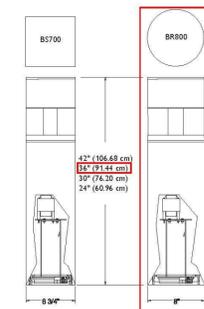

NOTE: Factory supplied template must be used when setting anchor bolts. Philips Gardco will not honor any claim for incorrect anchorage placement from failure to use factory supplied templates.

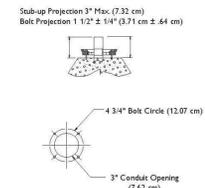

1611 Clovis Barker Road, San Marcos, TX 78666
(800) 227-0758 (512) 753-1000 FAX: (512) 753-7855 sitelighting.com
© 2011 Koninkl Philips Electronics N.V. All Rights Reserved.
Philips Gardco reserves the right to change materials or modify the design of its product without notification as part of the company's continuing product improvement program.
79115-33-0511



3 BOLLARD LIGHT
PRODUCT INFORMATION

N.T.S.

Bowman
CONSULTING

Bowman Consulting Group, Ltd.
101 South Street, S. E.
Leesburg, Virginia 20175
Phone: (703) 443-2400
Fax: (703) 443-2405
www.bowmanconsulting.com
© Bowman Consulting Group, Ltd.

LIGHTING DETAILS
CRESCENT PLACE
ZONING CONCEPT PLAN & PROFFER AMENDMENT
TLZM-2012-0003
LOUDOUN COUNTY, VIRGINIA
TOWN OF LEESBURG

DATE	DESCRIPTION
11/20/12	PER CHECKLIST COMMENTS
3/28/13	PER 1ST SUB. COMMENTS
6/14/13	PER 2ND SUB. COMMENTS
8/14/13	PER PC COMMENTS
9/18/13	PER PC COMMENTS
10/07/13	PER PC COMMENTS
10/18/13	PER PC COMMENTS
11/01/13	PER TC COMMENTS

DATE	DESCRIPTION
BBR DESIGN	JAE DRAWN
	CHKD
SCALE	H: N.T.S.
	V:

JOB No. 5371-01-003
DATE NOVEMBER 5, 2012
FILE No. 5371-D-ZP-001